



Date: 06.08.2022

To,

Sanskriti Srivastava

C/o Kumar Mangalam University, Gurugram
R/o House No.387, First Floor, Sector 9, Gurugram - 122001
email - sanskriti.srivastava55@gmail.com
Mobile - 6201276288

Sub - Internship Letter

We are pleased to offer you internship in our Company Sanjeev Furnishers Pvt. Ltd. for a period of six months w.e.f. 04.07.2022 to 04.01.2023. You will be paid stipend as per the industry standards. We feel confident, you will be able to learn and enhance your Architectural and Interior Designing Skill through practical experience.

With Good wishes

For Sanjeev Furnishers Pvt. Ltd.



Registrar
K.R. Mangalam University
Sohna Road, Gurugram (Haryana)

Sanjeev Furnishers Pvt. Ltd.



Head Office : R-552, 2nd Floor, Shankar Road, New Rajinder Nagar, New Delhi- 110060, INDIA



011-28741050, 011-45088541



www.sfprojects.co.in



Date - 26.12.2022


INTERNSHIP CERTIFICATE

This is to certify that Ms. Sanskriti Srivastava pursuing Bachelor of Interior Designing from K.R. Mangalam University, Gurugram, Haryana has successfully completed her internship of 7 Months from 04 July 2022 - 04 February 2023 with Sanjeev Furnishers Private Limited - New Delhi.

During her tenure, she worked on various projects such as Banks Interior & MNC. She contributed in working drawings, elevations & sections. She is a very dedicated, diligent, seeking and a good team member.

We wish her good luck for her future endeavors.

Sanjeev Furnishers Private Limited

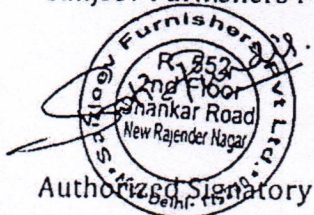



INTERNSHIP

COURSE CODE- APID417A

SANSKRITI SRIVASTAVA
1906810005
B.I.D, 4TH YEAR
BATCH - 2019-2023

INDEX

BANKS/ INSTITUTE

IDFC

East of Kailash

- Naraina - (Area - 1874 sq.ft)
- Bareilly - (Area - 4315.62 sq.ft)
- Badarpur - (Area - 2038 sq.ft)
- Tughlakabad - (Area - 1103.21 sq.ft)
- (Area - 785 sq.ft)

HDFC

Srinagar (Batamalo)

- (Area - 1111 sq.ft)

Yes Bank

Model Town

- Gaur City - (Area - 1582 sq.ft)
- Patrakarpuram - (Area - 1160 sq.ft)
- Sector 7 (Gurgaon) - (Area - 1736.6 sq.ft)
- (Area - 1403 sq.ft)

Axis Bank

Amritsar

- Dhungargarth - (Area - 1150 sq.ft)
- Gurgaon - (Area - 884.17 sq.ft)
- Hirapur - (Area - 2436.78 sq.ft)
- (Area - 873.43 sq.ft)

AU Bank

Lucknow

- (Area - 5220 sq.ft)

Aakash

Chandkheda

- Vasant Kunj - (Area - 8427 sq.ft)
- (Area - 14592 sq.ft)

COMMERCIAL PROJECTS

Incuspace

Corenthum Tower 2nd Floor

- Corenthum Tower 3rd Floor - (Area - 12597 sq.ft)
- (Area - 13808.32 sq.ft)

Event Management Office (Naraina)

- (Area - 5172.16 sq.ft)

Krishna Apartment (P.G) (Rajendra Place)




- (Area - 1431.49 sq.ft)

APC Office (Palam Vihar), (Gurgaon)

- (Area - 2038 sq.ft)

Minimalism is beyond time. It is the stillness of perfection

-Massimo Vignelli

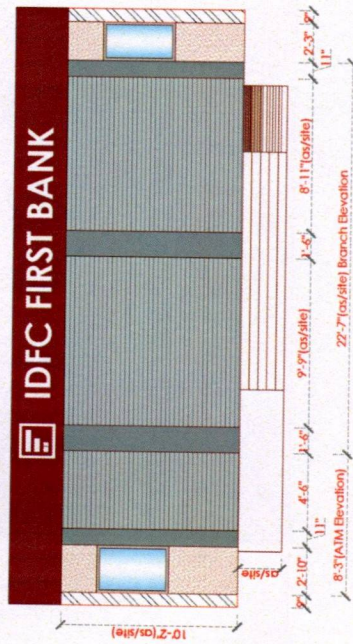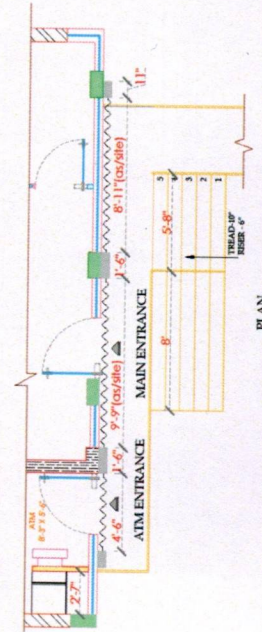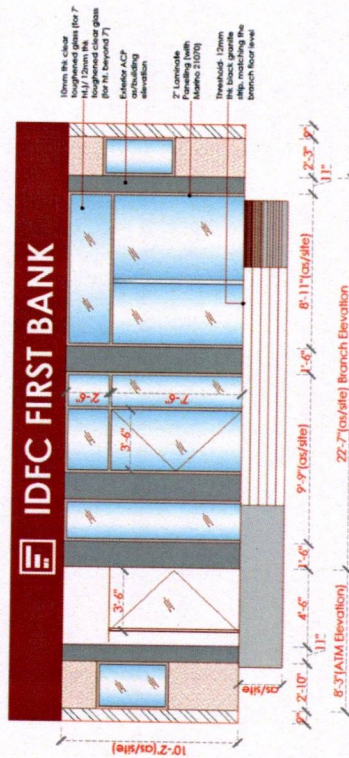 IDFC FIRST BANK IDFC FIRST BANK

PLAN


 R-552, Shantika Road, Sector 55, Gurgaon, New Delhi 110066, INDIA	PROJECT : DFC, EAST OF KAILASH	DRAWING TITLE : FRONT ELEVATION	DESIGNED BY	==	DRAWING NUMBER
			DRAWN BY	==	
			SCALE	==	
			DATE	==	
			REV. DATE	==	

1 Bank Design

[illegible]

Engineers, Consultants & Turnkey Interiors	PROJECT :	IDFC, EAST OF KALASHI	DRAWING TITLE :	FURNITURE LAYOUT	DRAWING NUMBER
 R-552, Shankar Road, New Regdler Nagar, New Delhi, 110060, INDIA 011-26111060					1.1
	DESIGNED BY : --				
	DRAWN BY : --				
	SCALE : -- 1:1.5				
	DATE : -- 19-09-2022				
REV. DATE : --					

1 Bank Design

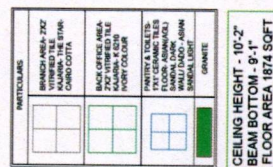


 Engineers, Consultant & Turnkey Interiors	PROJECT : IDFC, EAST OF KALASHI	DRAWING TITLE : FLOORING LAYOUT	DRAWING NUMBER	
			DRAWN BY :	1.4
			SCALE :	N.T.S
			DATE :	19-06-2022
			REV. DATE :	-










 sf R-352 Shankar Road 5th Floor, Sector-14, New Delhi, Delhi 110040, INDIA	Engineers, Consultant &turnkey Interiors	PROJECT : IDFC, EAST OF KAILASH	DRAWING TITLE : LOOPING LAYOUT	DESIGNED BY : -	DRAWING NUMBER : 1.8
				DRAWN BY : - SHASHWATI	
				SCALE : - M:1.5	
				DATE : - 19-08-2022	
				REV. DATE : -	

Section-AA'

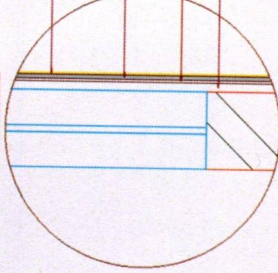

Section-BB'

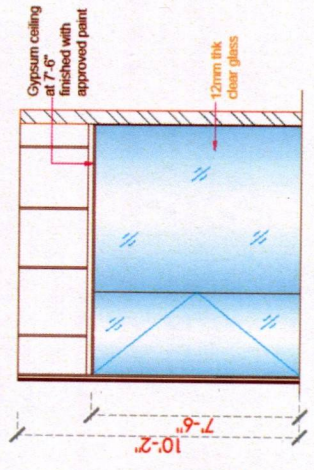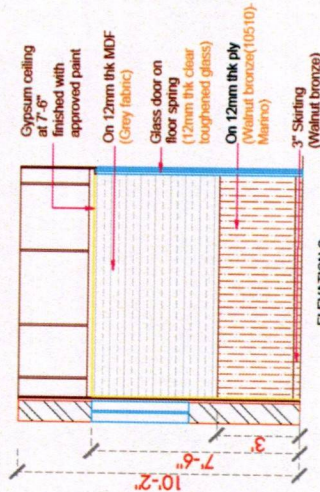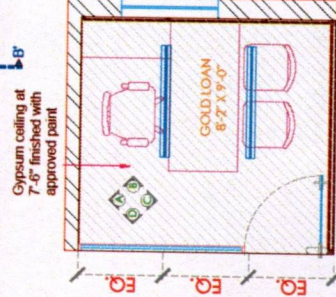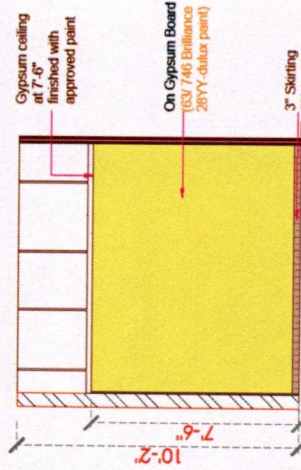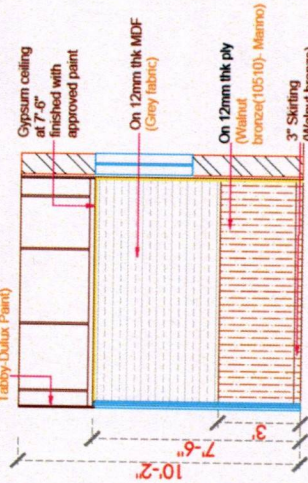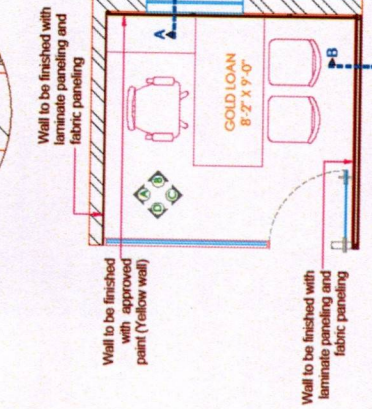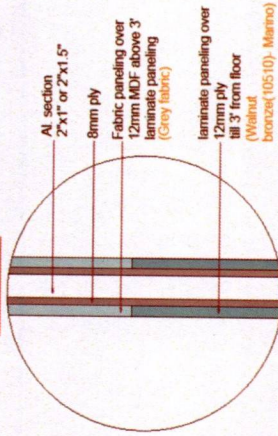

Engineers, Consultant & Turnkey Interiors

PROJECT :

IDFC,
EAST OF KAILASH








DRAWING TITLE :

GOLD LOAN DETAIL











DRAWING NUMBER

DESIGNED BY -
DRAWN BY - SANSKRITI
SCALE - N.T.S
DATE - 01-10-2022
REV. DATE -

R-552, Shankar Road,
New Rajinder Nagar, New Delhi,
Delhi 110060, INDIA.

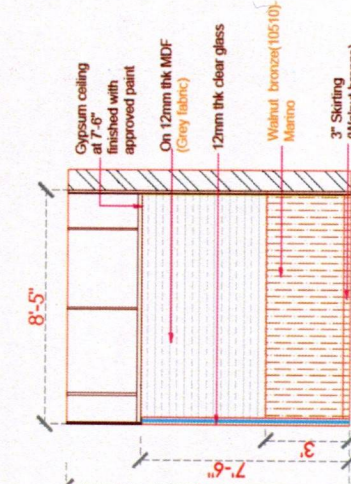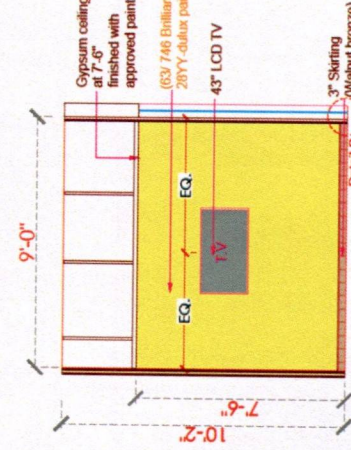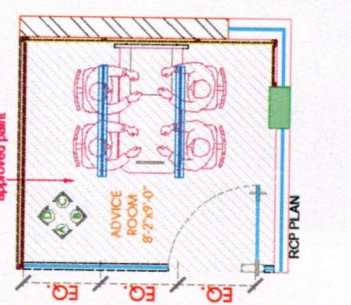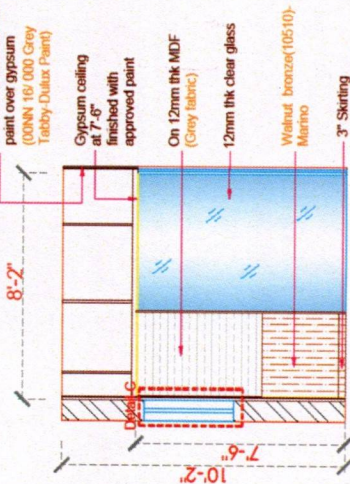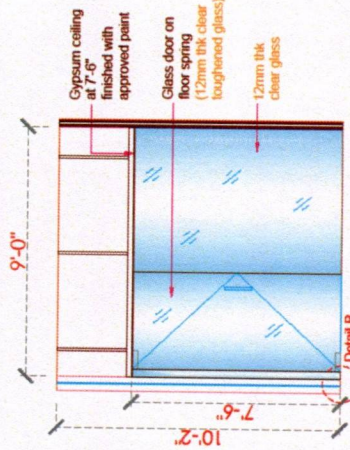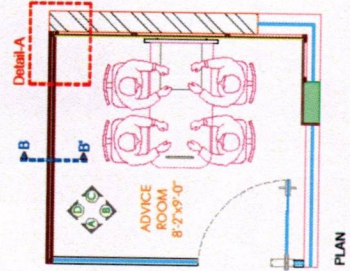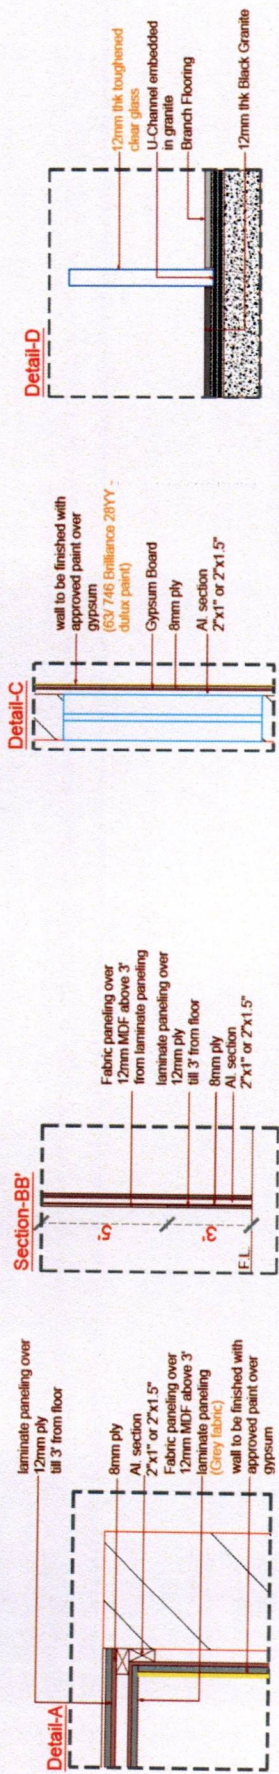

Engineers, Consultant & Turnkey Interiors  R-552, Shankar Road, New Rajinder Nagar, New Delhi, Delhi 110060, INDIA.	PROJECT : IDFC, EAST OF KAILASH	DRAWING TITLE : ADVICE ROOM DETAIL	DRAWING NUMBER	
			DESIGNED BY	-
			DRAWN BY	- SANSKRITI
			SCALE	- N.T.S
			DATE	- 01-10-2022
			REV. DATE	-

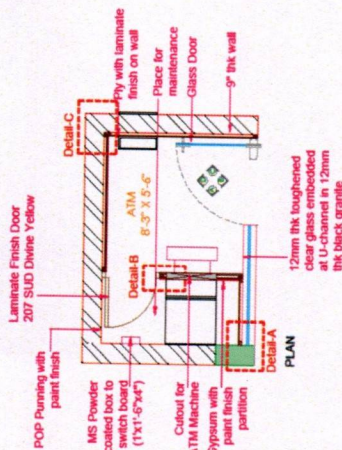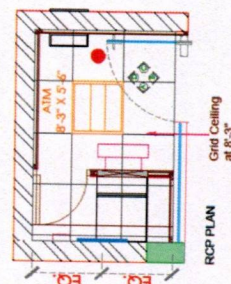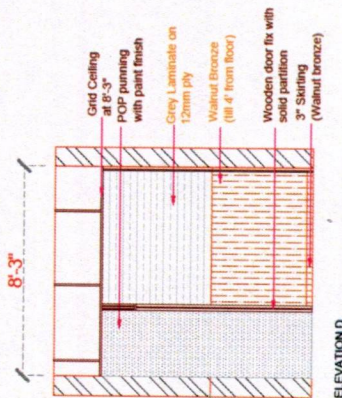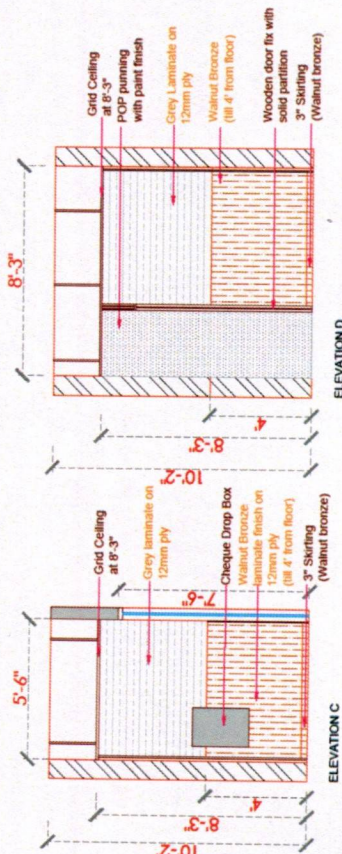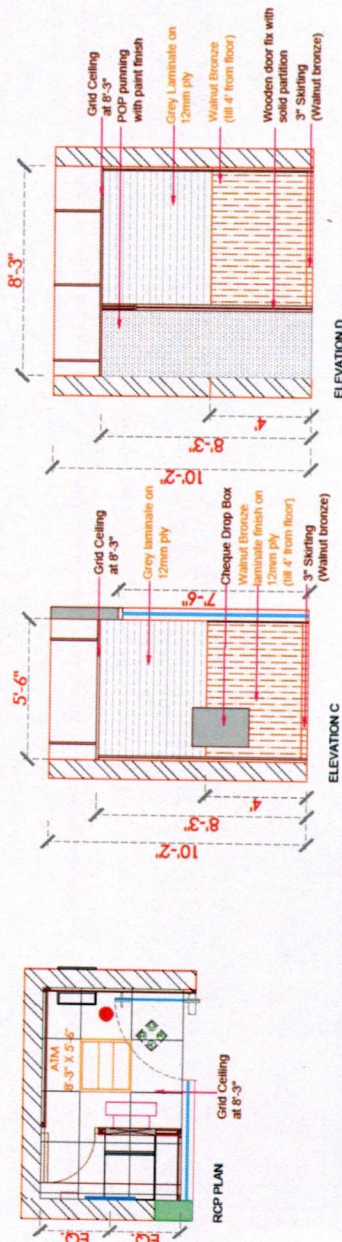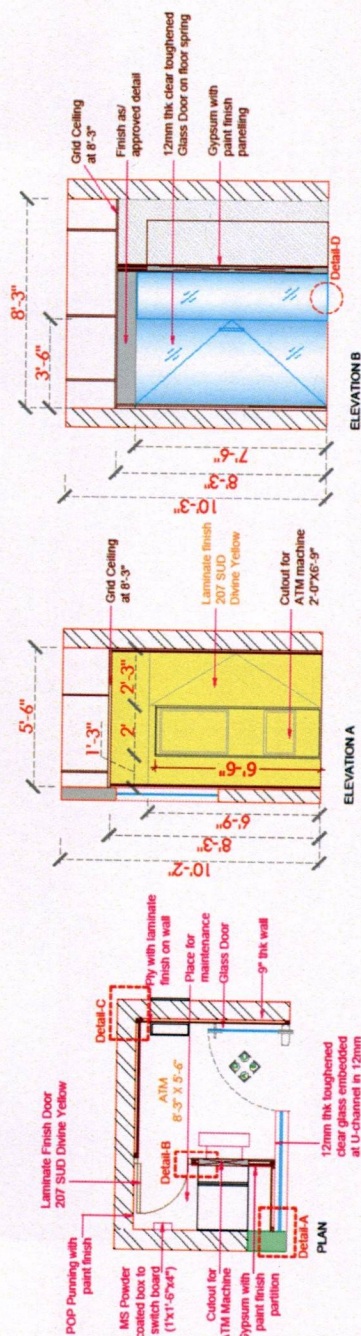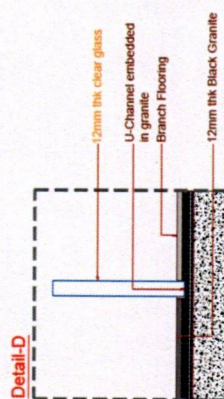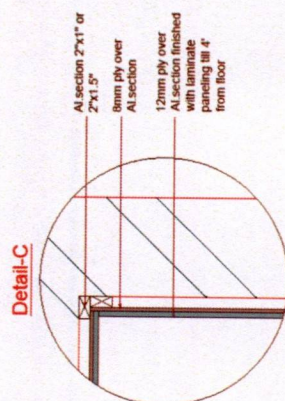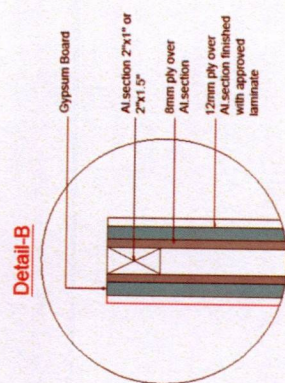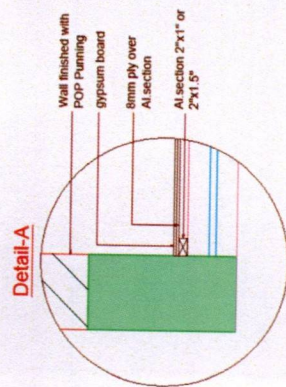

Engineers, Consultant & Turnkey Interiors

PROJECT :

DRAWING TITLE :

DRAWING NUMBER




R-552, Shankar Road,
New Rajinder Nagar, New Delhi,
Delhi 110060, INDIA.

**IDFC,
EAST OF KAILASH**






ATM DETAIL

DESIGNED BY	-	
DRAWN BY	-	SANSKRITI
SCALE	-	N.T.S
DATE	-	11-10-2022
REV. DATE	-	11-10-2022

Detail-A

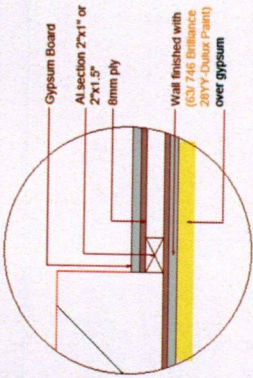

Detail-B

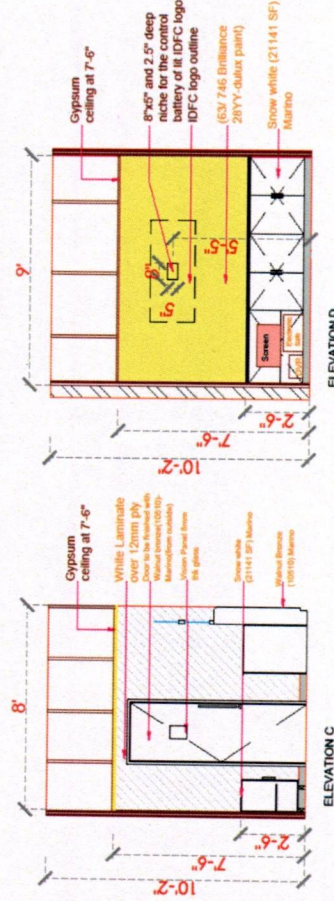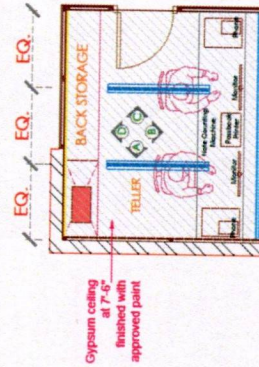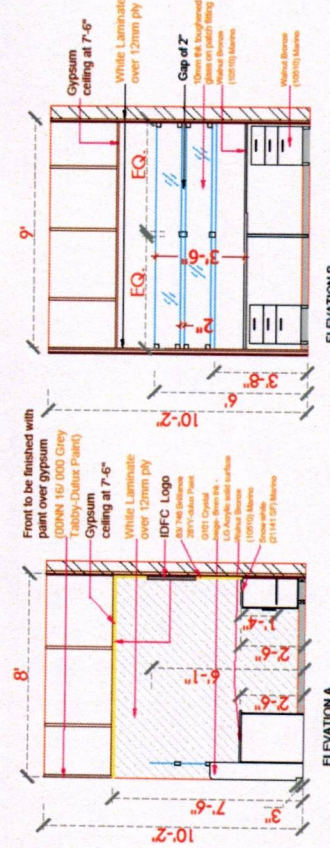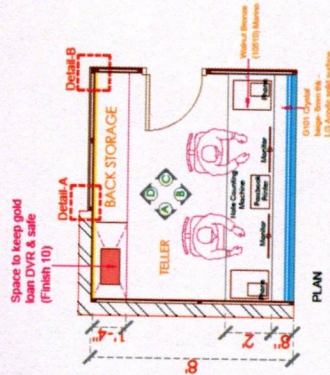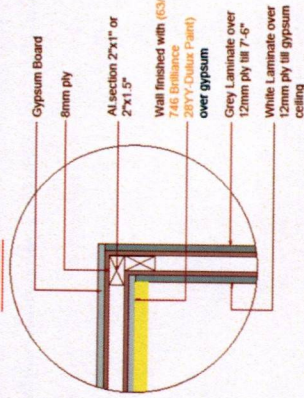


Engineers, Consultant & Turnkey Interiors

PROJECT :

DRAWING TITLE :

DRAWING NUMBER

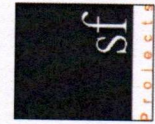



R-552, Shankar Road,
New Rajinder Nagar, New Delhi,
Delhi 110060, INDIA.

IDFC,
EAST OF KAILASH

TELLER DETAIL

DESIGNED BY -
DRAWN BY - SANSKRITI
SCALE - N.T.S
DATE - 01-10-2022
REV. DATE -

1.11

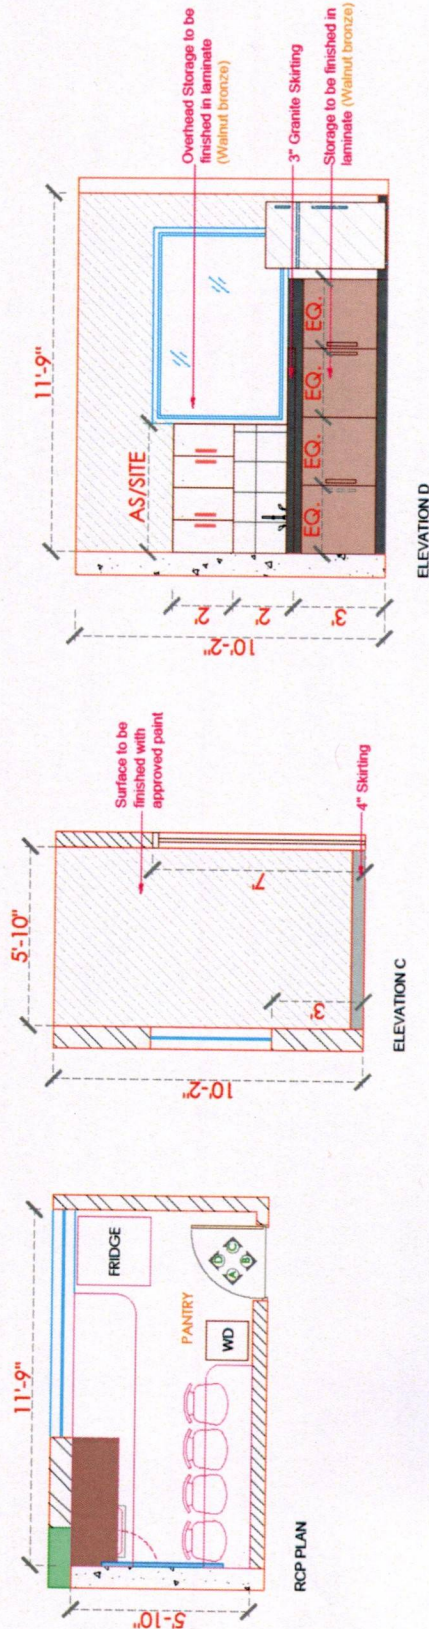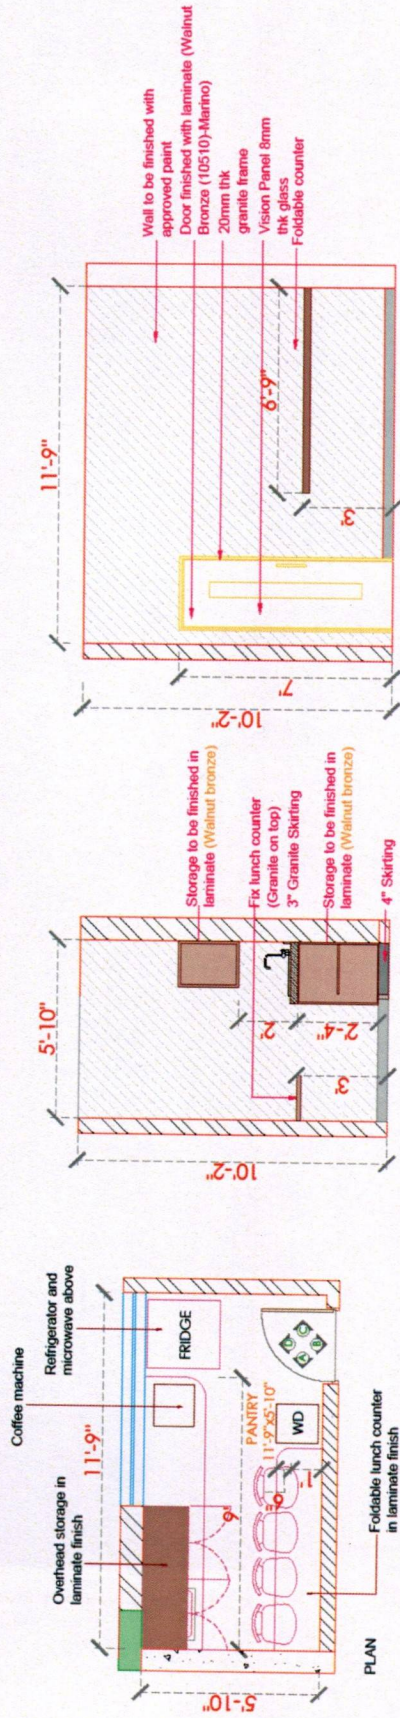

Engineers, Consultant & Turnkey Interiors

PROJECT :

DRAWING TITLE :

DRAWING NUMBER




R-552, Shankar Road,
New Rajinder Nagar, New Delhi,
Delhi 110060, INDIA.

IDFC,
EAST OF KAILASH

PANTRY DETAIL

DESIGNED BY -
DRAWN BY - SANSKRITI
SCALE - N.T.S
DATE - 01-10-2022
REV. DATE -

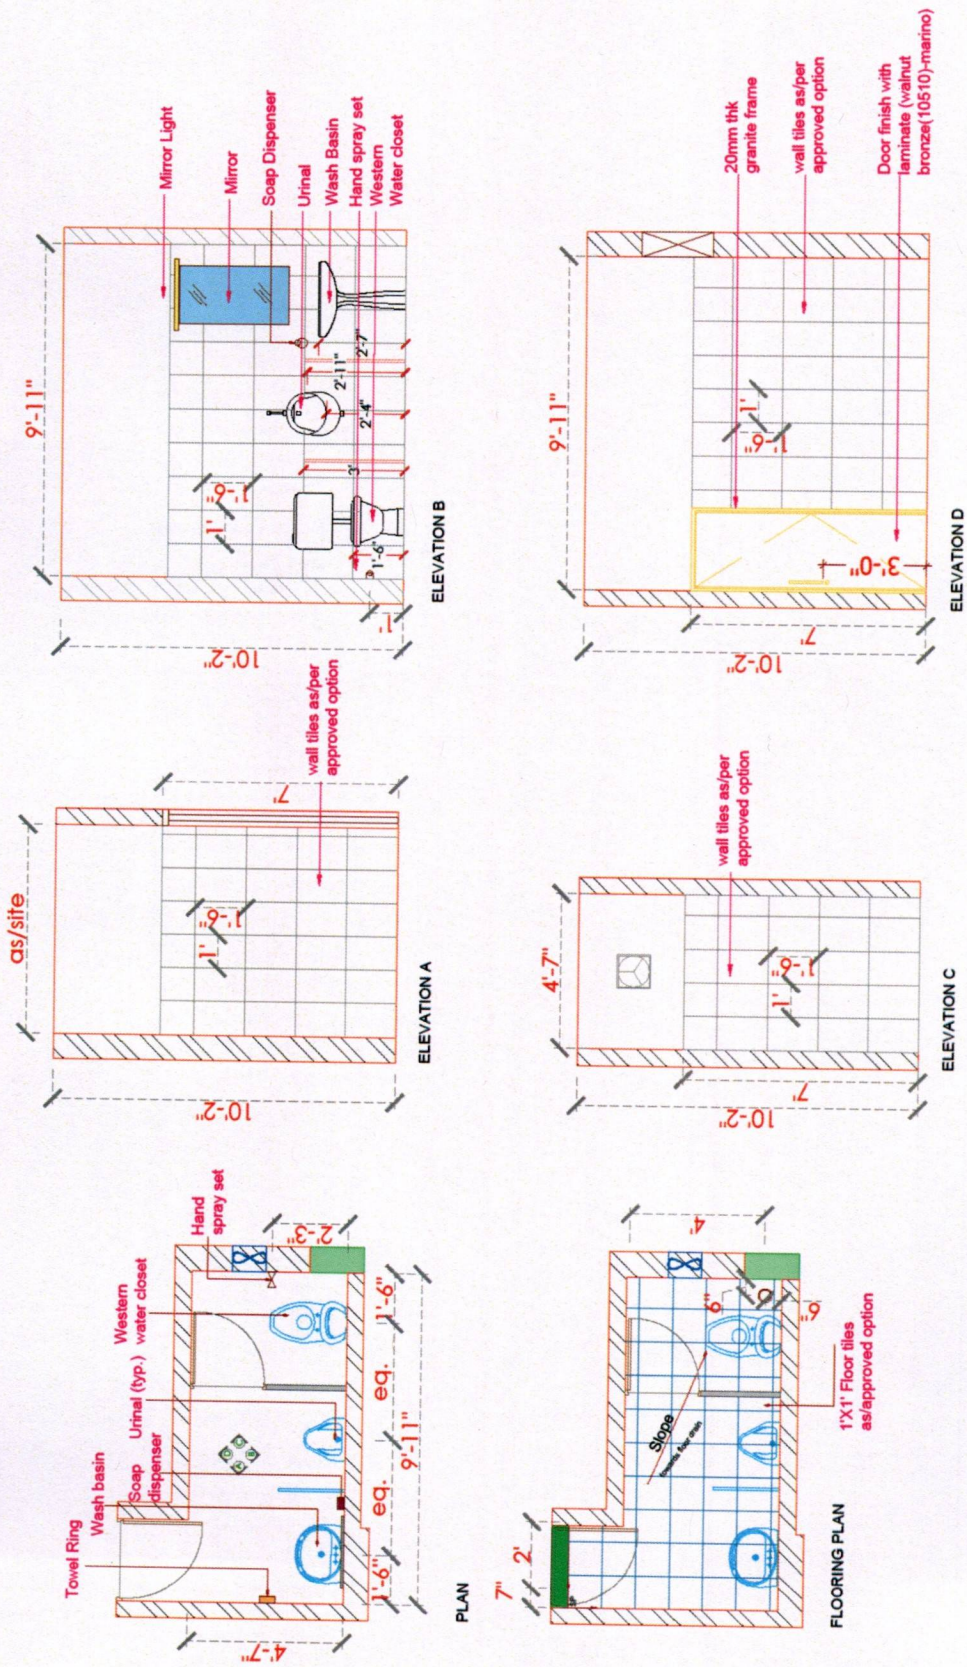

Engineers, Consultant & Turnkey Interiors

PROJECT :

IDFC,
EAST OF KAILASH

DRAWING TITLE :

GENTS TOILET DETAIL

DRAWING NUMBER

DESIGNED BY - SANSKRITI

DRAWN BY - N.T.S




SCALE - 01-10-2022

DATE -

REV. DATE -









 Sankar Engineering & Construction Pvt. Ltd. 9-552, Shankar Road, New Pimpri-Chinchwad, New Delhi 110060, INDIA.	Engineers, Consultant & turnkey Interiors	PROJECT :	IDFC EAST OF KALASH	DRAWING TITLE :	RACEWAY LAYOUT	DESIGNED BY : - SANSR/RTI	SHANKAR NUMBER 1,7	
						DRAWN BY : - SANSR/RTI		
						SCALE : - N.T.S		
						DATE : - 19-08-2022		
						REV. DATE : -		

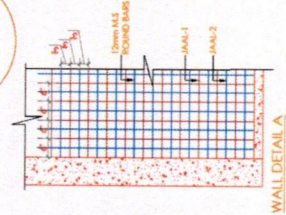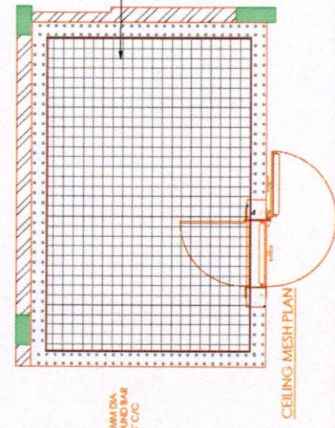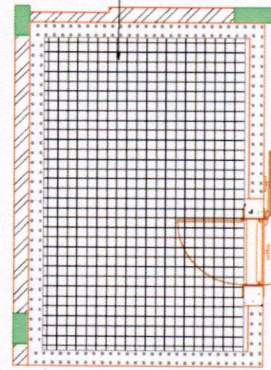


 Engineers, Consultants & Turnkey Interiors R-552, Shantkar Road, New Rajinder Nagar, New Delhi,	PROJECT : DPC, EAST OF KAILASH	DRAWING TITLE : STRONG ROOM DETAIL	(#)	DESIGNED BY	--	SOURCE NUMBER 1.17	
				DRAWN BY	--		SANSKRITI
				SCALE	--		N.T.S
				DATE	--		28.08.2022










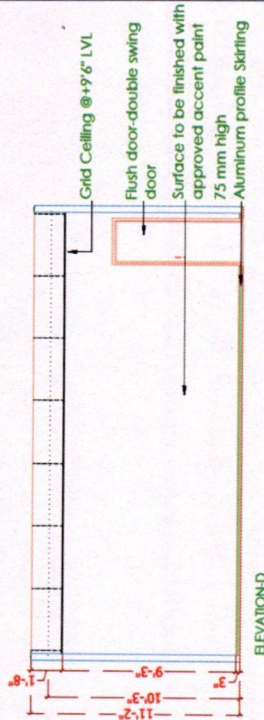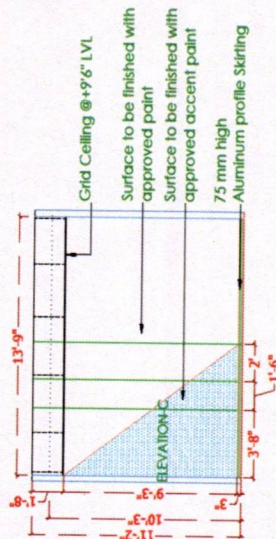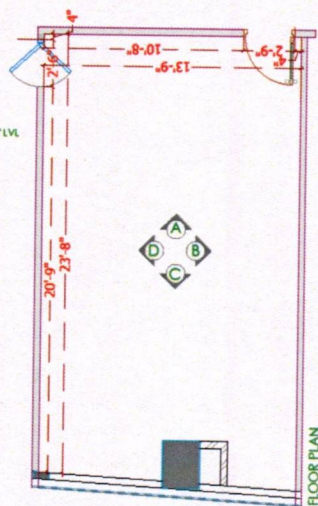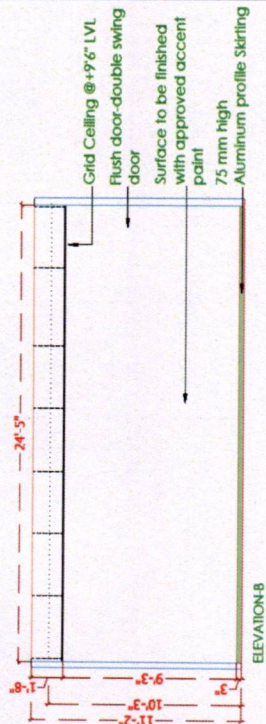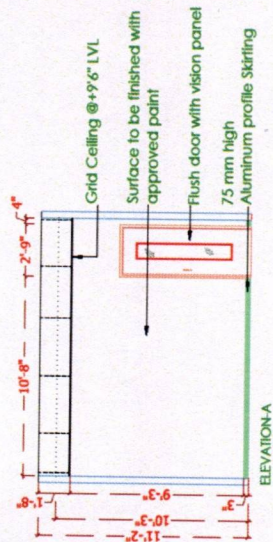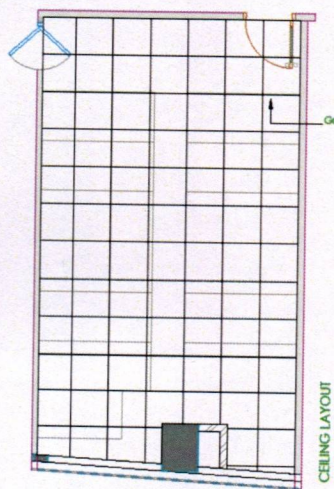

CEILING HEIGHT - 11'2"
BEAM BOTTOM - 10'3"
FLOOR AREA - SQFT - 14952

Engineers, Consultant & Turnkey Interiors  R-552, Shankar Road, New Rajinder Nagar, New Delhi, Delhi 110060, INDIA.	PROJECT : AAKASH VASANT KUNJ	DRAWING TITLE : CLASS ROOM	DRAWING NUMBER	
			DESIGNED BY	-
			DRAWN BY	- SANSKRITI
			SCALE	- N.T.S
			DATE	- 15-11-2022
			REV. DATE	-
			 N 	

 

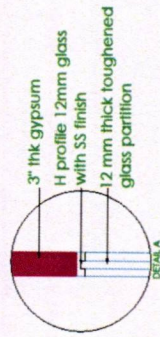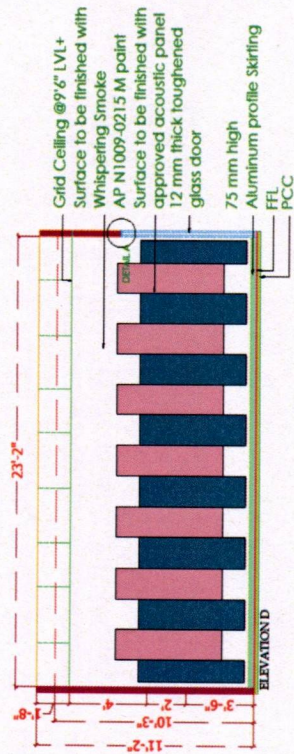
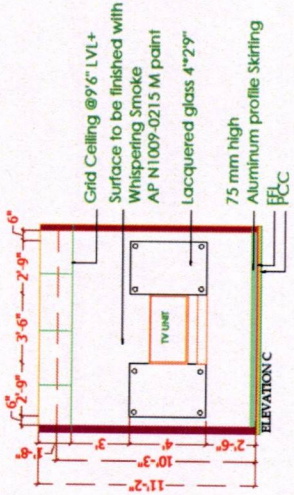
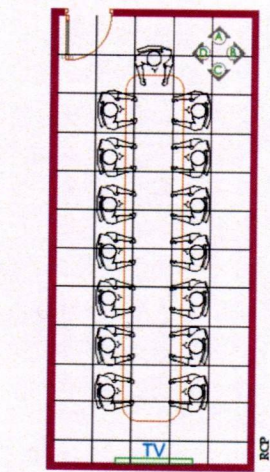
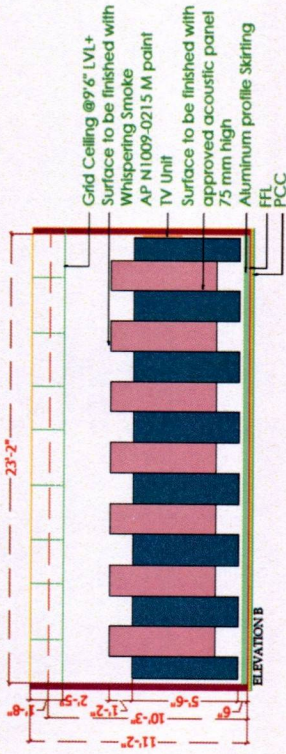
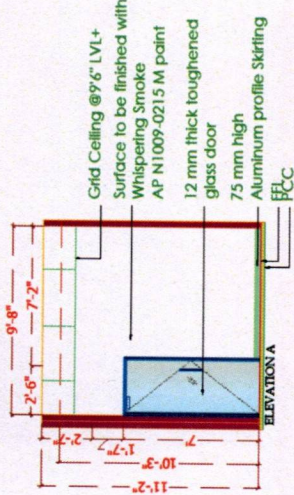
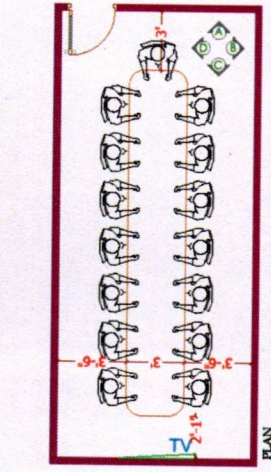


CEILING HEIGHT - 11'2"
BEAM BOTTOM - 10'3"
FLOOR AREA - 149.52

Engineers, Consultant & Turnkey Interiors  R-552, Shankar Road, New Rajinder Nagar, New Delhi, Delhi 110060, INDIA.	PROJECT : AAKASH VASANT KUNJ	DRAWING TITLE : CONFERENCE ROOM	DRAWING NUMBER	
			DESIGNED BY	—
			DRAWN BY	— SANSKRITI
			SCALE	— N.T.S
			DATE	— 15-11-2022
			REV. DATE	—
				



R-552, Shankar Road,
New Rajinder Nagar, New Delhi,
Delhi 110060, INDIA.

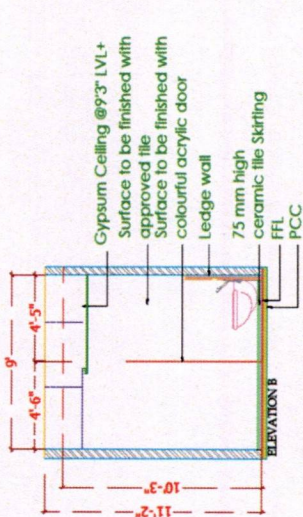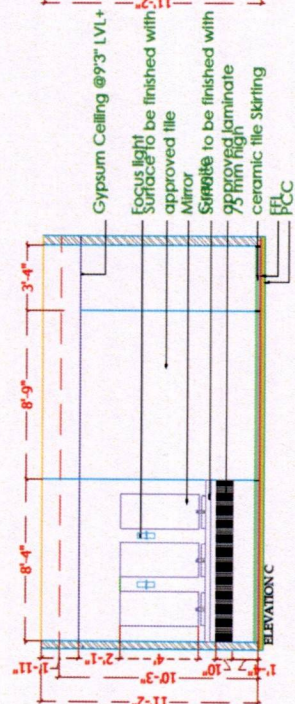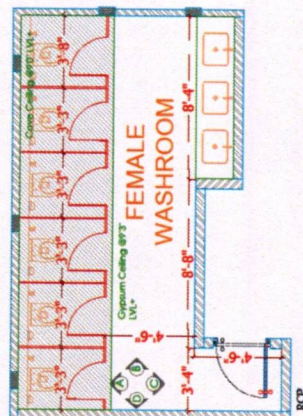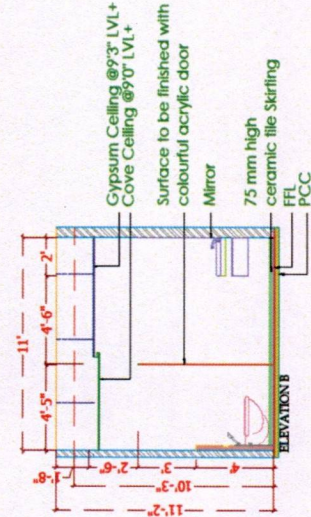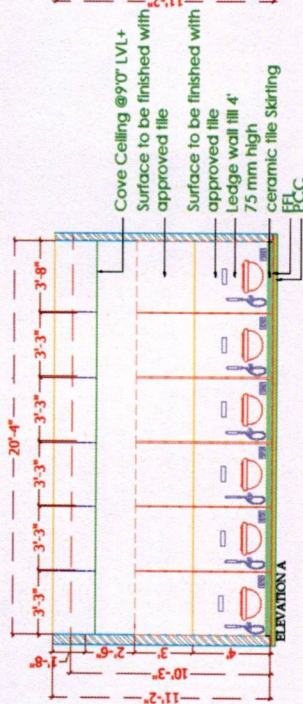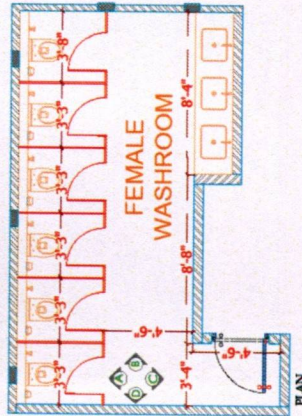

CEILING HEIGHT - 11'2"
BEAM BOTTOM - 10'3"
FLOOR AREA SQFT - 14952

Engineers, Consultant & Turnkey Interiors



R-552, Shankar Road,
New Rajinder Nagar, New Delhi,
Delhi 110060, INDIA.

PROJECT :


AAKASH
VASANT KUNJ








DRAWING TITLE :

F. TOILET

DRAWING NUMBER

DESIGNED BY	-
DRAWN BY	- SANSKRITI
SCALE	- N.T.S
DATE	- 15-11-2022
REV. DATE	-

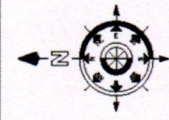

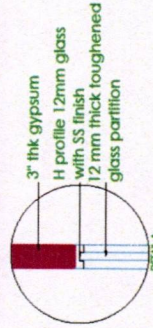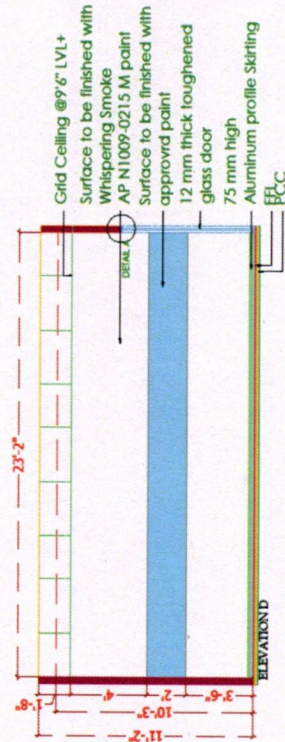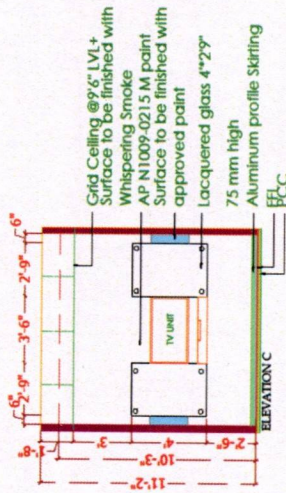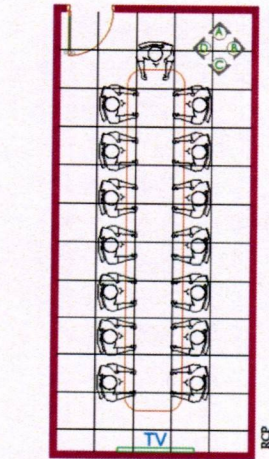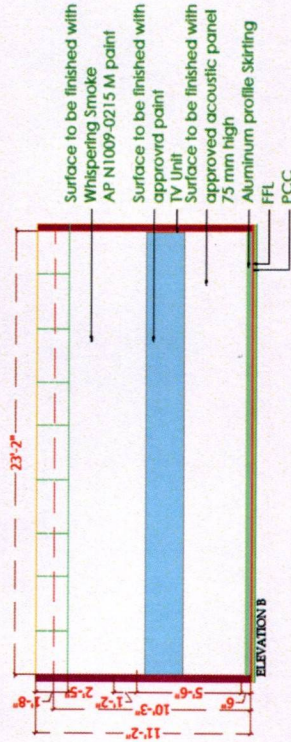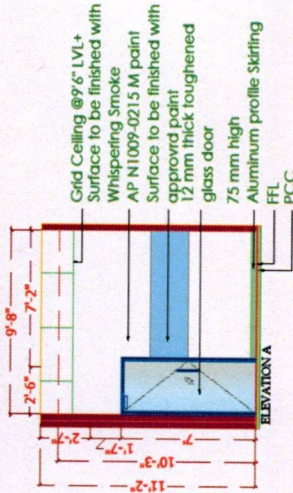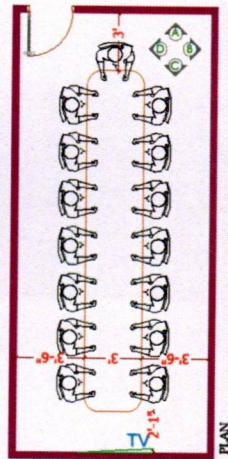

CEILING HEIGHT - 11'2"
BEAM BOTTOM - 10'3"
FLOOR AREA SQFT - 14952

Engineers, Consultant & Turnkey Interiors



R-552, Shankar Road,
New Rajinder Nagar, New Delhi,
Delhi 110060, INDIA.

PROJECT :

AAKASH
VASANT KUNJ







DRAWING TITLE :

CONFERENCE ROOM

DRAWING NUMBER

DESIGNED BY	-
DRAWN BY	- SANSKRITI
SCALE	- N.T.S
DATE	- 15-11-2022
REV. DATE	-



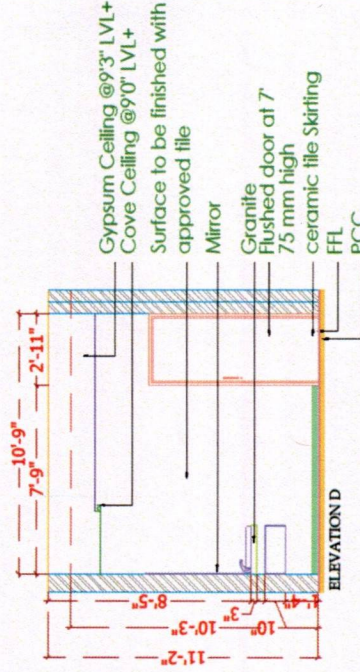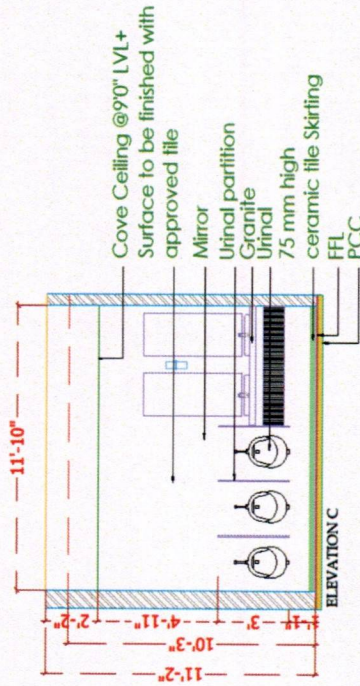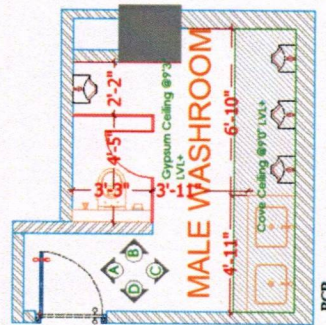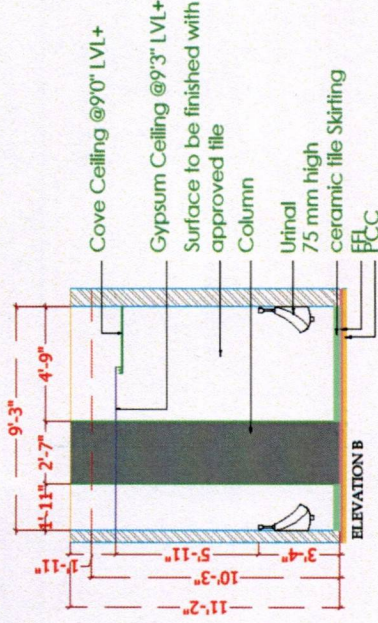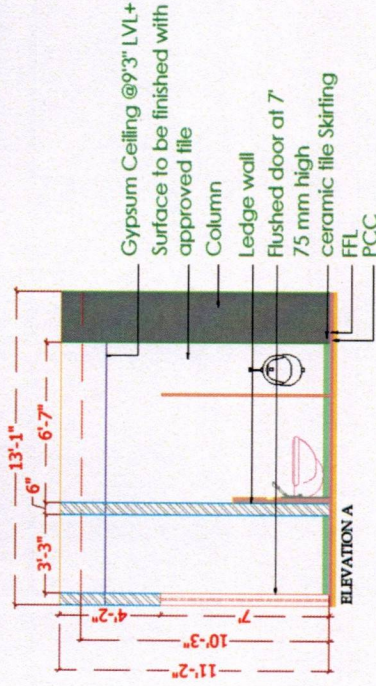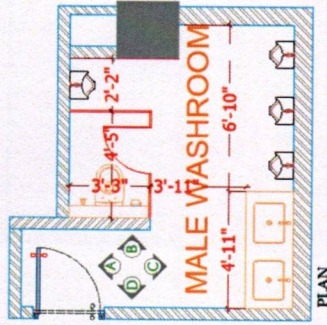

CEILING HEIGHT - 11'2"
BEAM BOTTOM - 10'3"
FLOOR AREA SQFT - 14952

Engineers, Consultant & Turnkey Interiors

sf
16010060

R-552, Shankar Road,
 New Rajinder Nagar, New Delhi,
 Delhi 110060, INDIA.

PROJECT :


**AAKASH
 VASANT KUNJ**






DRAWING TITLE :

G. TOILET


DRAWING NUMBER

DESIGNED BY	-
DRAWN BY	- SANSKRITI
SCALE	- N.T.S
DATE	- 15-11-2022
REV. DATE	-

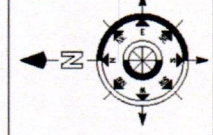

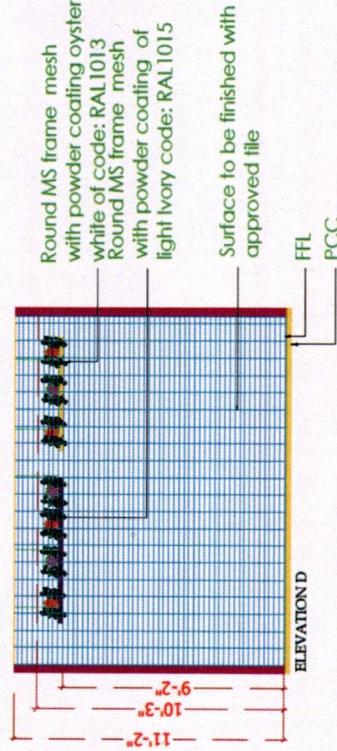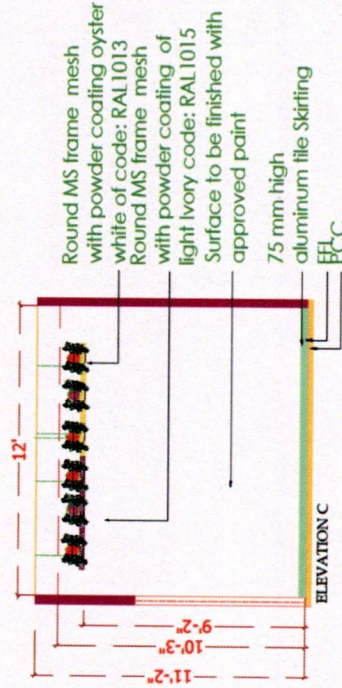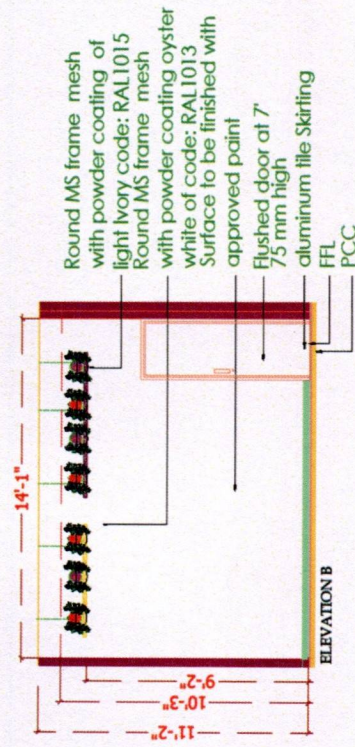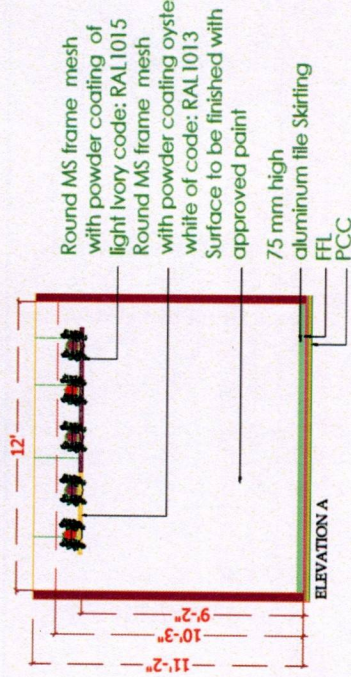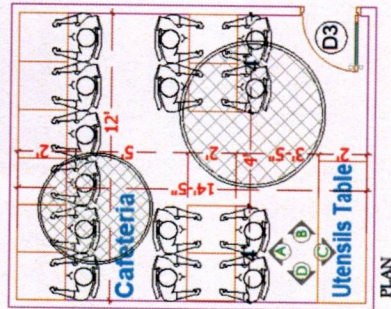

CEILING HEIGHT - 11'2"
BEAM BOTTOM - 10'3"
FLOOR AREA SQFT - 14952

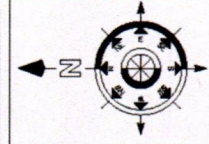

Engineers, Consultant & Turnkey Interiors



R-552, Shankar Road,
New Rajinder Nagar, New Delhi,
Delhi 110060, INDIA.

PROJECT :



AAKASH
VASANT KUNJ

DRAWING TITLE :

CAFETERIA

DRAWING NUMBER

DESIGNED BY	-
DRAWN BY	- SANSKRITI
SCALE	- N.T.S
DATE	- 15-11-2022
REV. DATE	-

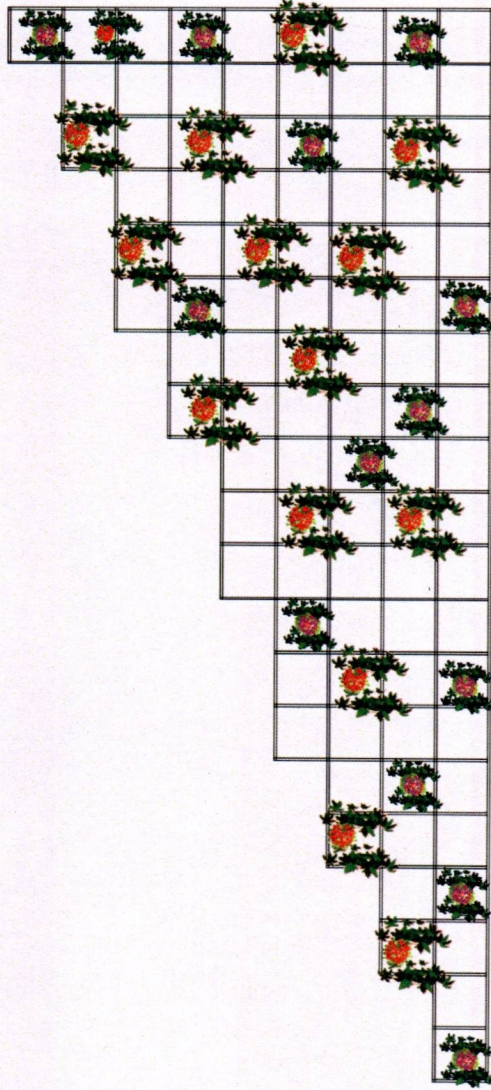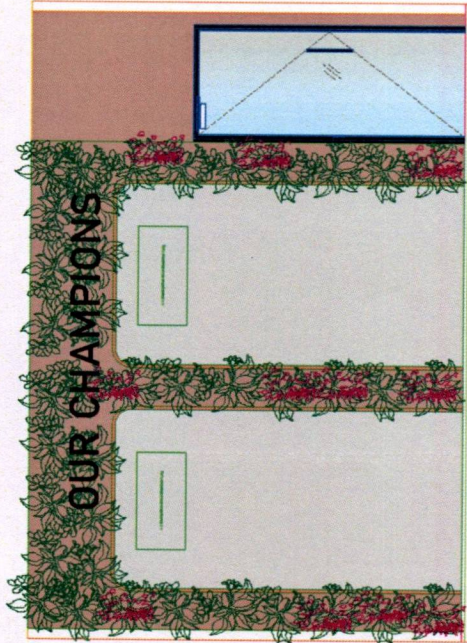



CEILING HEIGHT - 11'2"
BEAM BOTTOM - 10'3"
FLOOR AREA SQFT

Engineers, Consultant & Turnkey Interiors  R-552, Shankar Road, New Rajinder Nagar, New Delhi, Delhi 110060, INDIA.	PROJECT : AAKASH VASANT KUNJ	DRAWING TITLE : CAFETERIA	DRAWING NUMBER	
			DESIGNED BY	—
			DRAWN BY	— SANSKRITI
			SCALE	— N.T.S
			DATE	— 15-11-2022
			REV. DATE	—



R-552, Shankar Road,
New Rajinder Nagar, New Delhi,
Delhi 110060, INDIA.

WORKSTATION:385
AREA - 12620.14 SQ. FT
BEAM DEPTH 1'-6"

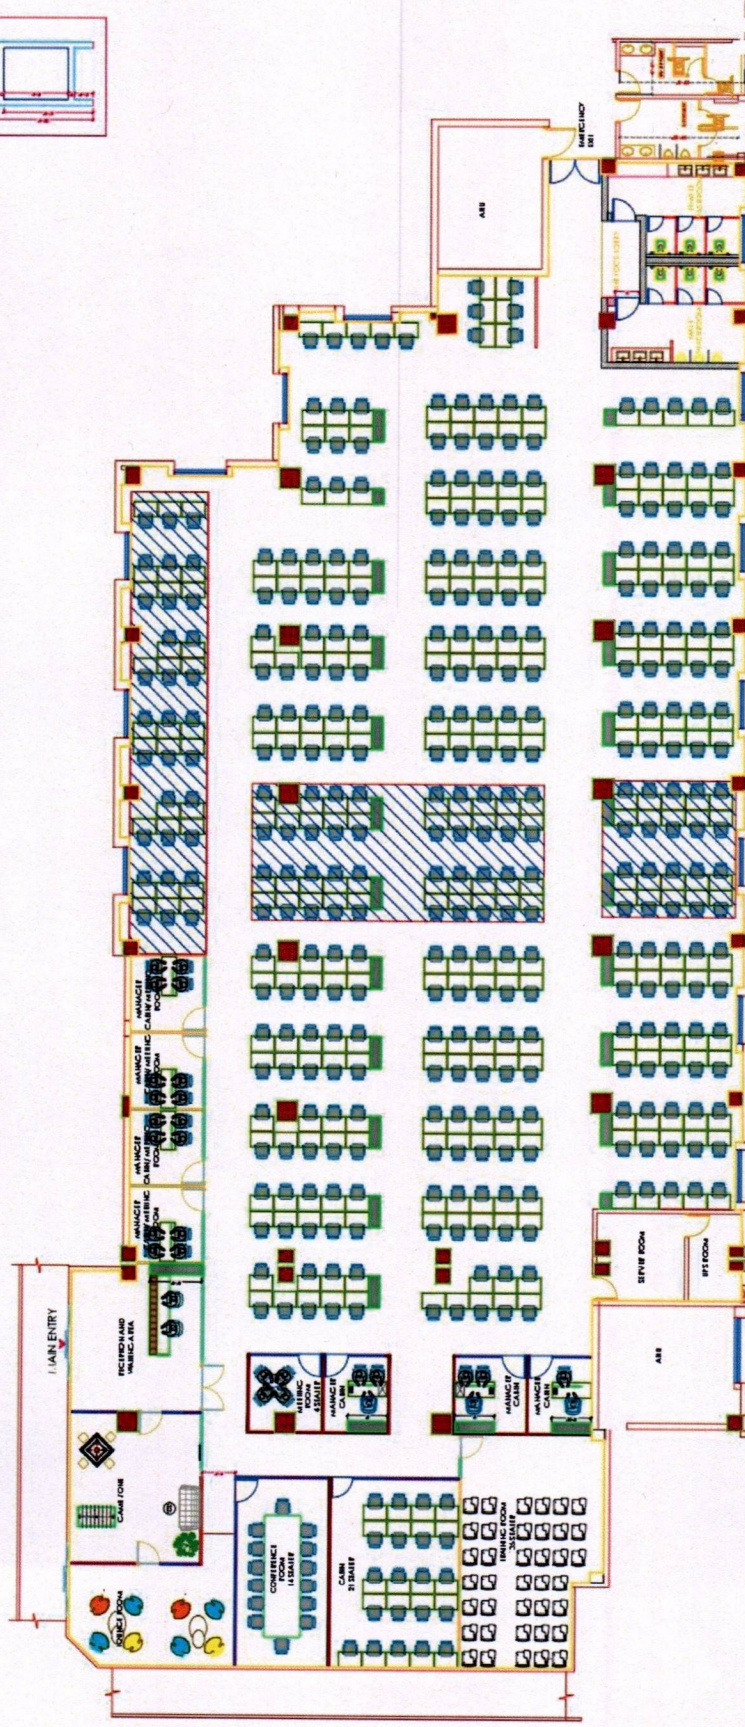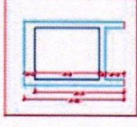


Engineers, Consultant &Turnkey Interiors sf projects R-552, Shankar Road, New Rajinder Nagar, New Delhi, Delhi 110060, INDIA	PROJECT : INCUSPAZE 2nd FLOOR	DRAWING TITLE : FURNITURE LAYOUT	DRAWING NUMBER	
			DESIGNED BY	-
			DRAWN BY	- SANSKRITI
			SCALE	- N.T.S
			DATE	- 02-07-2022
			REV. DATE	-



R-552, Shankar Road,
New Rajinder Nagar, New Delhi,
Delhi 110060, INDIA

WORKSTATION-385
AREA - 12620.14 SQ. FT.

LEGEND	
	STONE TILE-RECEPTION
	CARPET FLOORING
	STONE TILE
	VITRIFIED FLOORING
	JET-BLACK GRANITE
	CARPET FLOORING
	CARPET

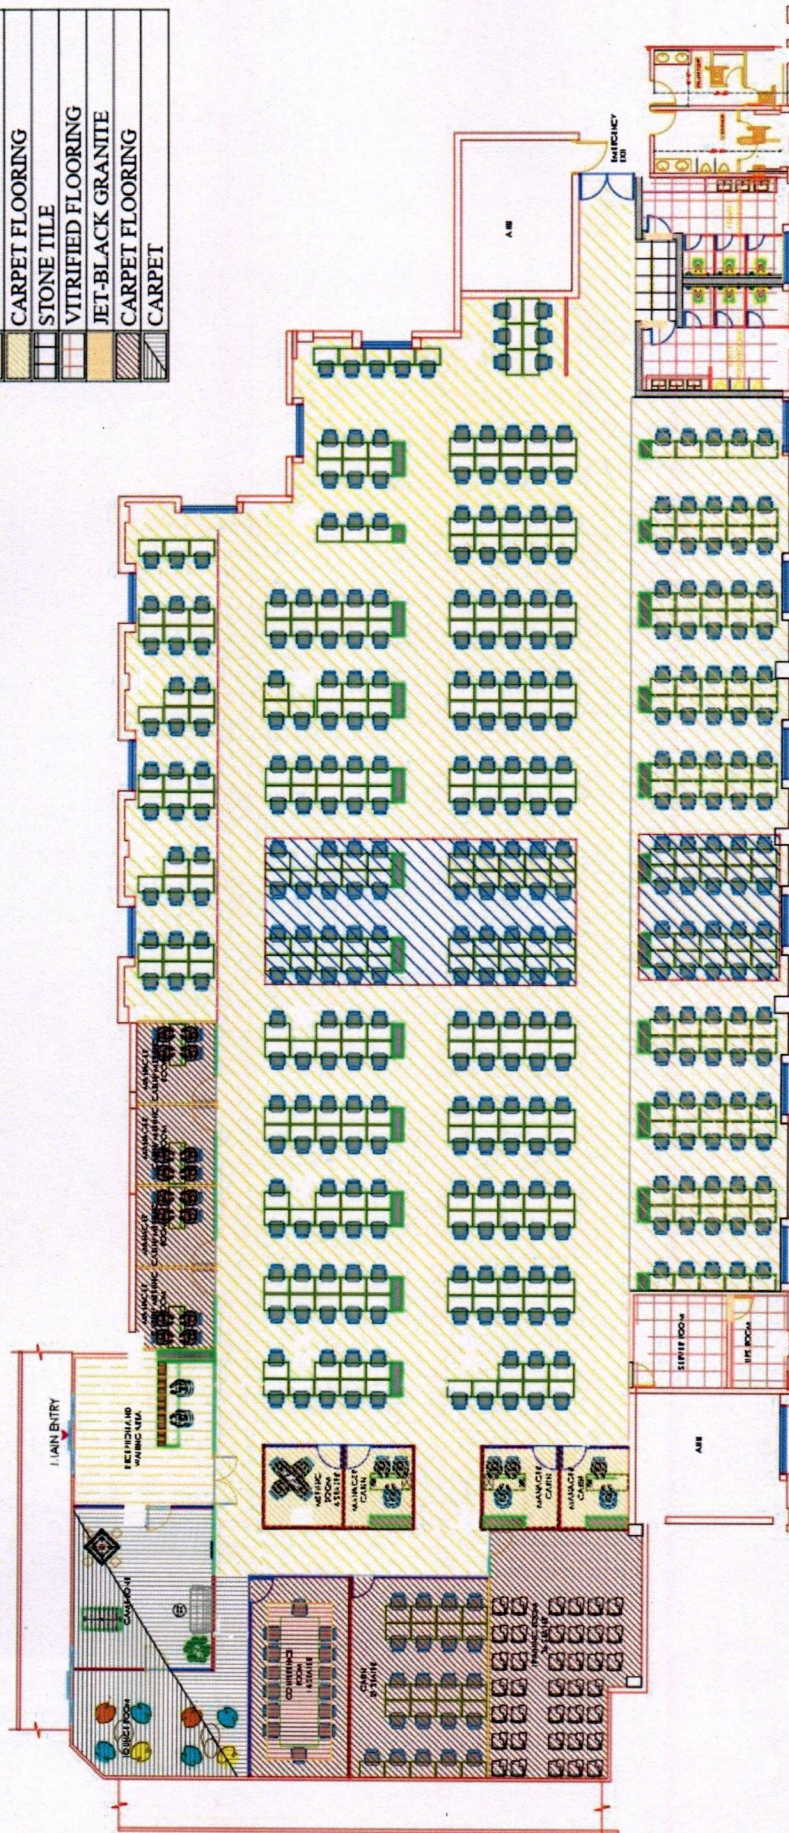

Engineers, Consultant & Turnkey Interiors

PROJECT:
INCUSPAZE
2nd FLOOR







DRAWING TITLE :
FLOORING

DRAWING NUMBER



R-552, Shankar Road,
New Rajinder Nagar, New Delhi,
Delhi 110060, INDIA

DESIGNED BY	-
DRAWN BY	- SANSKRITI
SCALE	- N.T.S
DATE	- 02-07-2022
REV. DATE	-

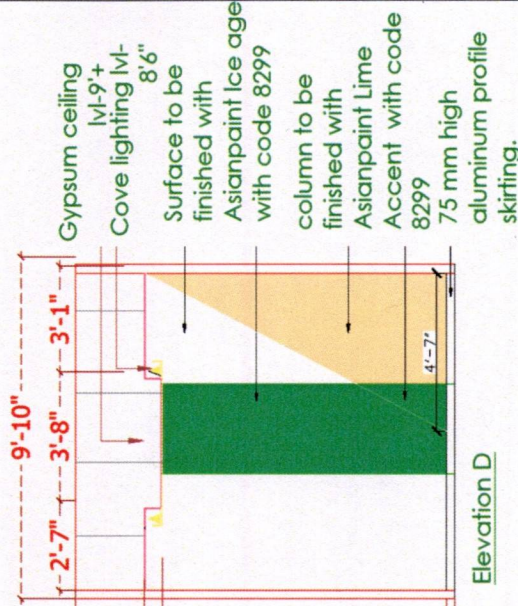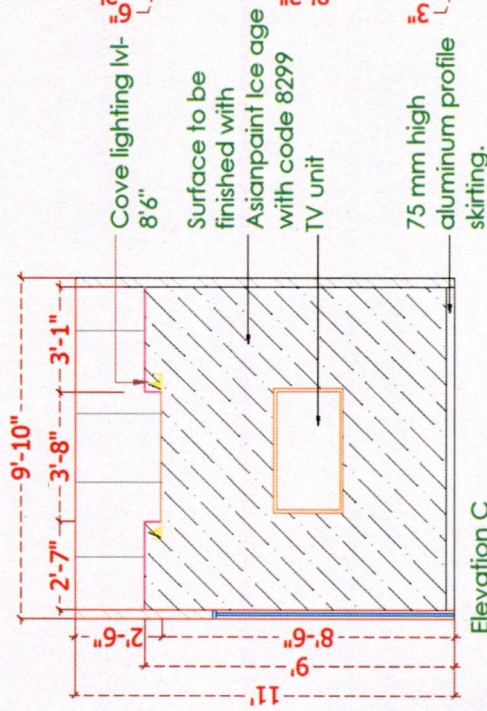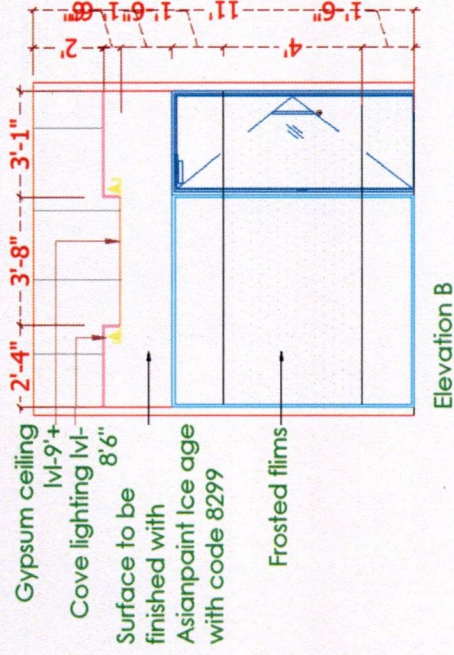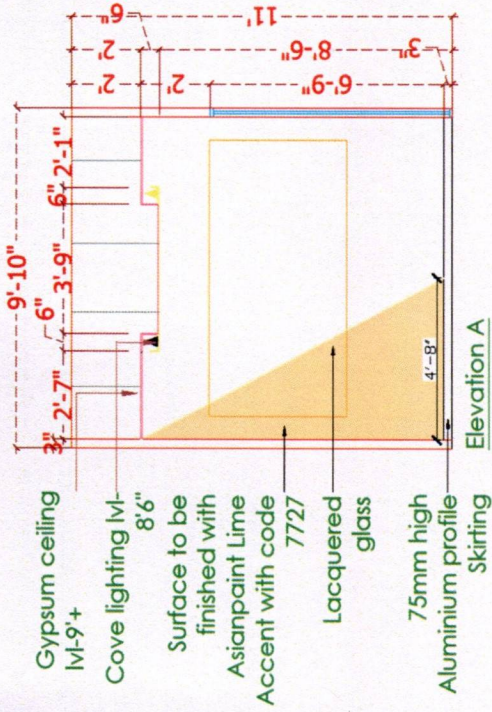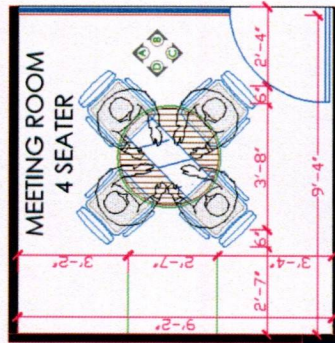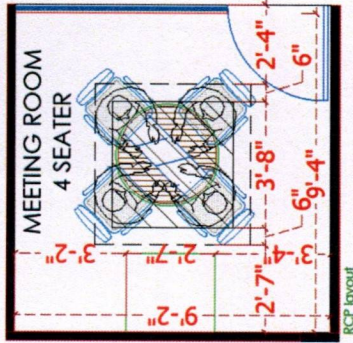

Engineers, Consultant & Turnkey Interiors






R-552, Shankar Road,
New Rajinder Nagar, New Delhi,
Delhi 110060, INDIA

PROJECT :
INCUSPAZE
2nd FLOOR

DRAWING TITLE :
MEETING ROOM - 4 SEATER

DESIGNED BY	-	DRAWING NUMBER
DRAWN BY	-	SANSKRITI
SCALE	-	N.T.S
DATE	-	02-07-2022
REV. DATE	-	

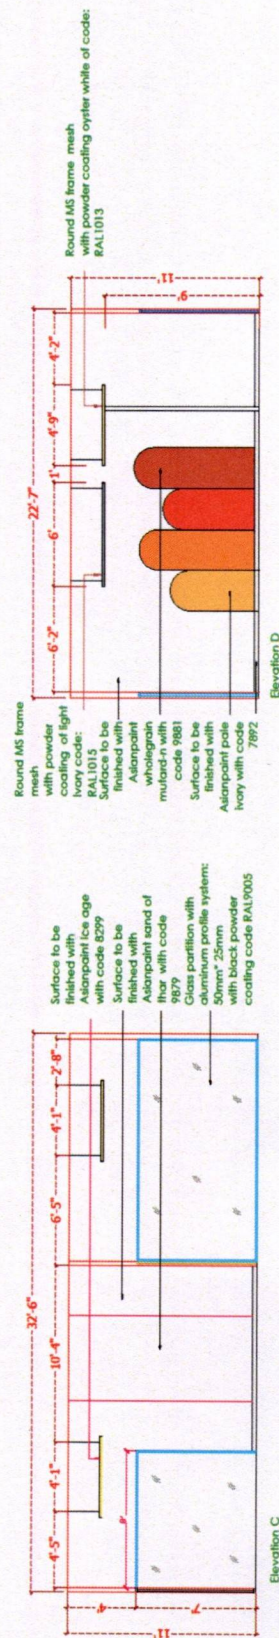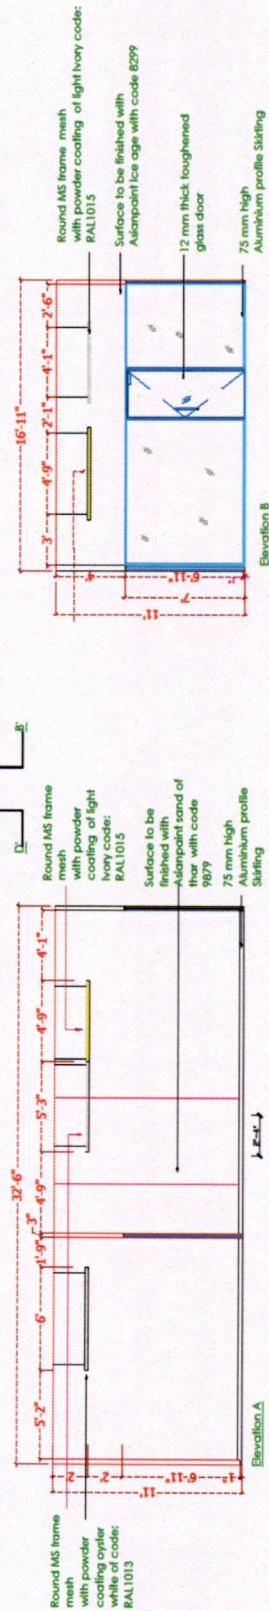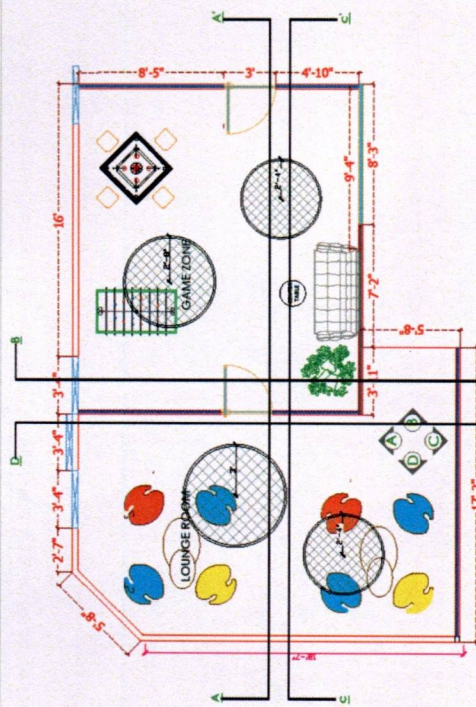

Engineers, Consultant & Turnkey Interiors









R-552 Shankar Road,
New Rajinder Nagar, New Delhi,
Delhi 110060, INDIA

PROJECT :
INCUSPAZE
2nd FLOOR

DRAWING TITLE :
LOUNGE ROOM and
GAME ROOM

DESIGNED BY	—	DRAWING NUMBER
DRAWN BY	—	SANSKRITI
SCALE	—	N.T.S
DATE	—	02-07-2022
REV.	DATE	—

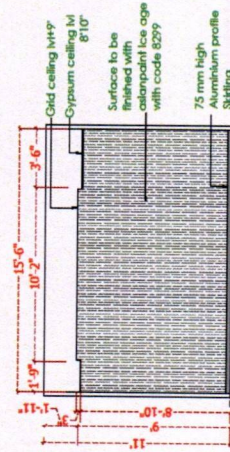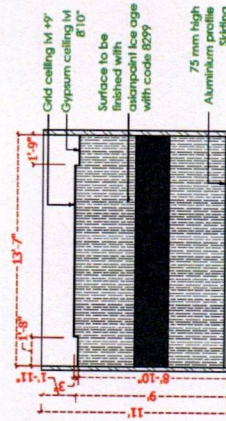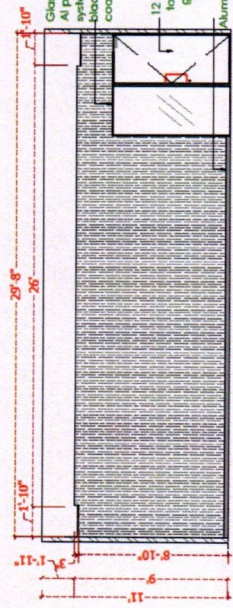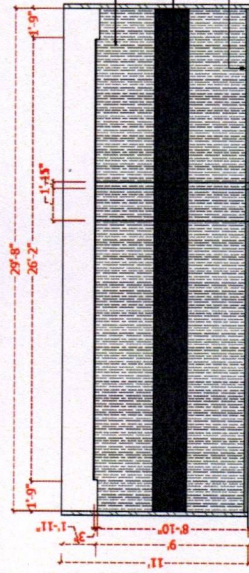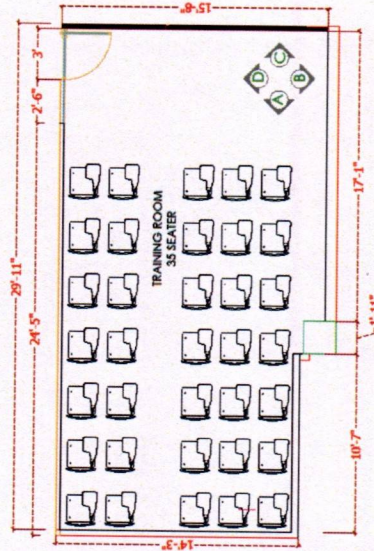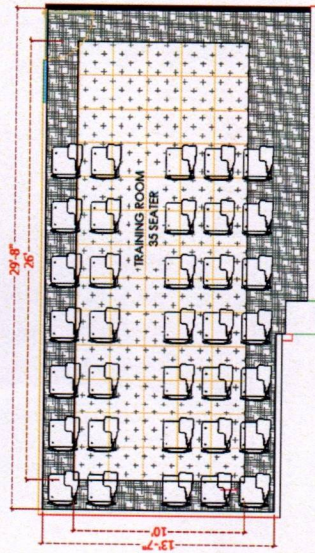


Engineers, Consultant & Turnkey Interiors

PROJECT :
INCUSPAZE
2nd FLOOR




DRAWING TITLE :
TRAINING
ROOM
35 SEATER

DRAWING NUMBER




DESIGNED BY -
DRAWN BY - SANSKRITI
SCALE - N.T.S
DATE - 02-07-2022
REV. DATE -

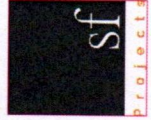

R-552, Shalimar Road,
New Rajinder Nagar, New Delhi,
Delhi 110060, INDIA

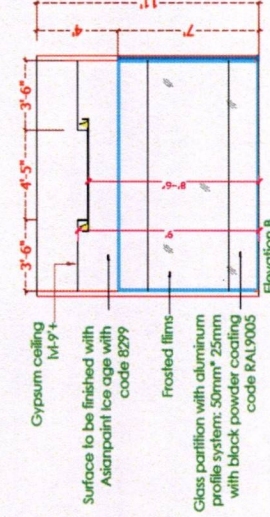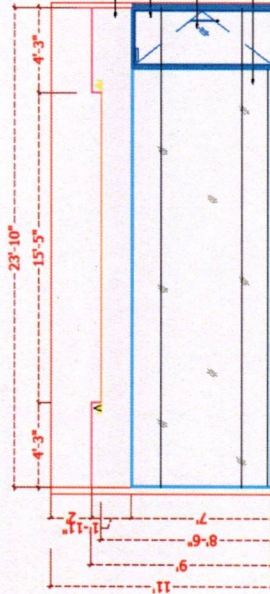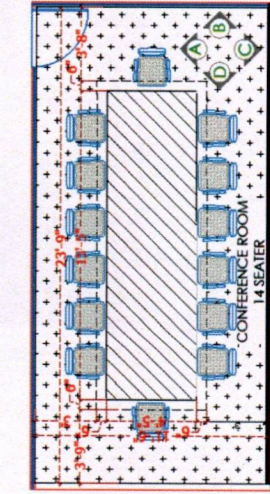


Surface to be finished with Asanpaint Ice age with code 8299 toughened glass door Frosted films Glass partition with aluminum profile system: 50mm* 25mm with black powder coating code RAL9005

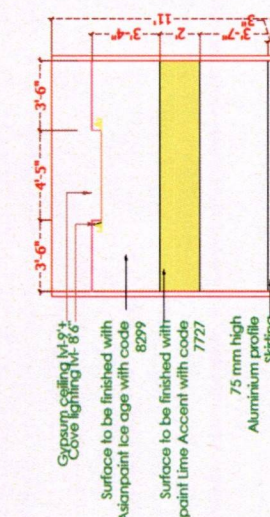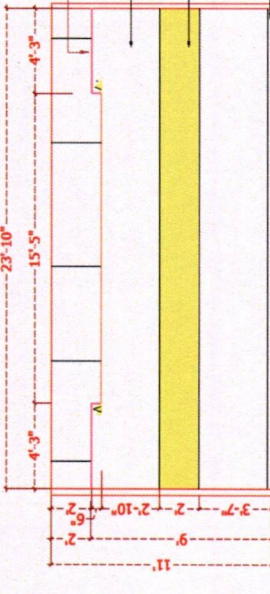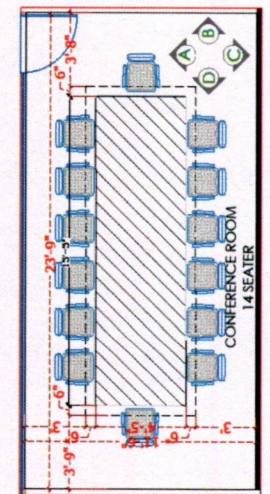

Cove lighting M-86 Surface to be finished with Asanpaint Ice age with code 8299 toughened glass door Frosted films Glass partition with aluminum profile system: 50mm* 25mm with black powder coating code RAL9005

Engineers, Consultant & Turnkey Interiors

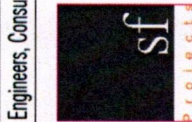







R-552, Shankar Road,
New Rajinder Nagar, New Delhi,
Delhi 110060, INDIA.

PROJECT :
INCUSPAZE
2nd FLOOR

DRAWING TITLE :
CONFERENCE
ROOM
14 SEATER

DRAWING NUMBER

DESIGNED BY -
DRAWN BY - SANSKRITI
SCALE - N.T.S
DATE - 02-07-2022
REV. DATE -

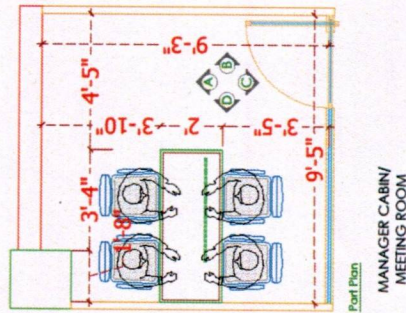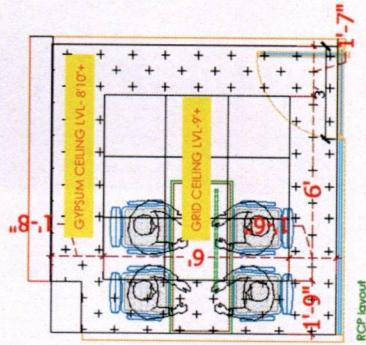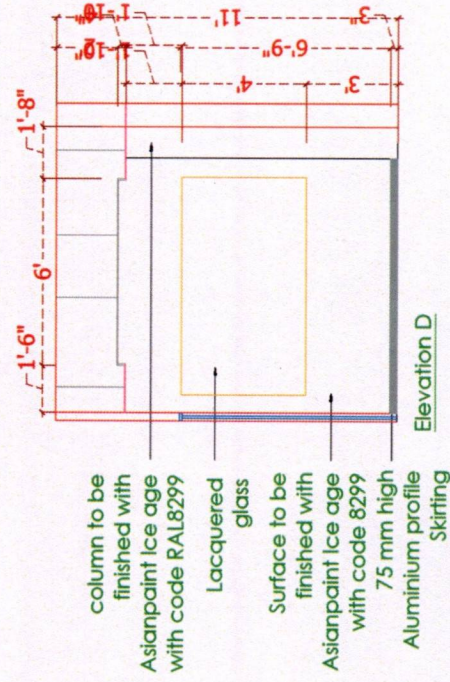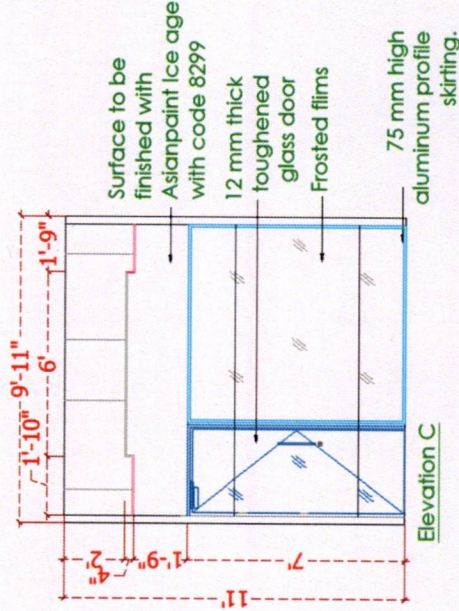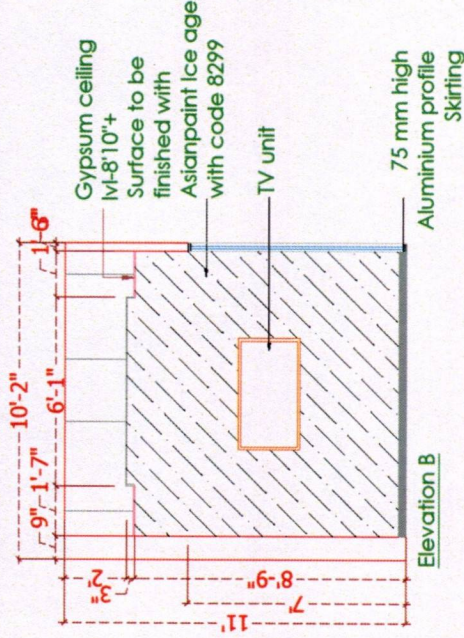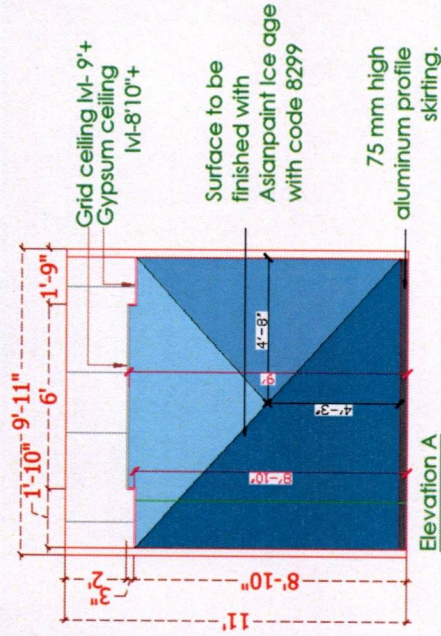

Engineers, Consultant & Turnkey Interiors

PROJECT :

INCUSPAZE
2nd FLOOR

 
DRAWING TITLE :






MANAGER CABIN/
MEETING ROOM

DRAWING NUMBER

DESIGNED BY -
DRAWN BY - SANSKRITI
SCALE - N.T.S
DATE - 02-07-2022
REV. DATE -

R-552, Shankar Road,
New Rajinder Nagar, New Delhi,
Delhi 110060, INDIA.



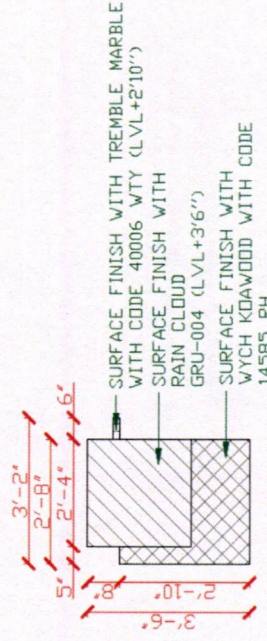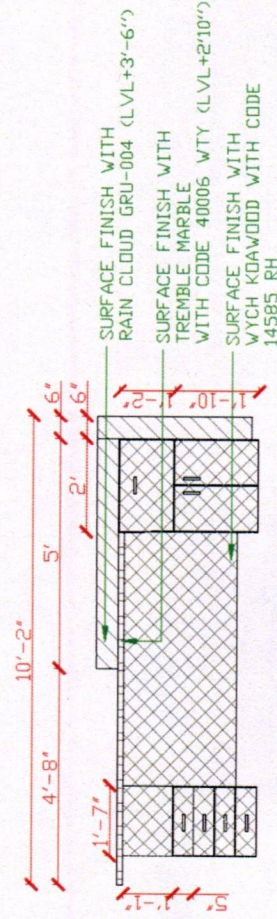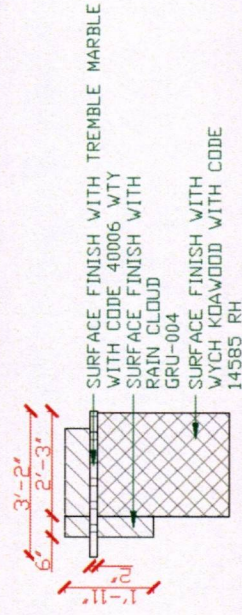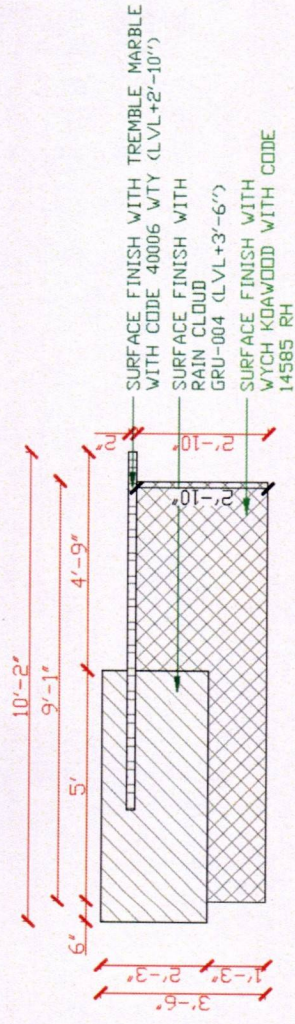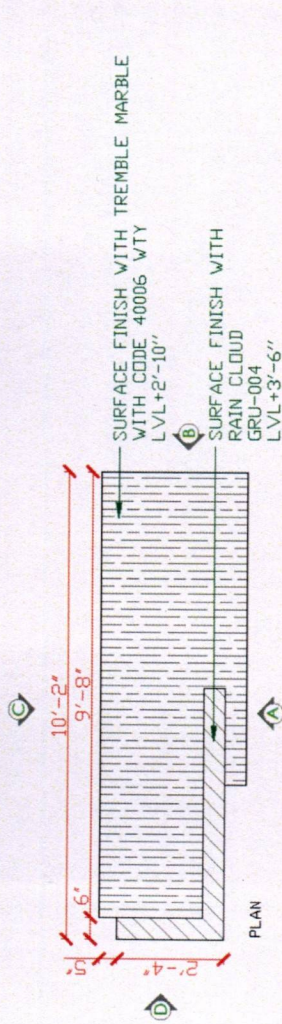

Engineers, Consultant & Turnkey Interiors

PROJECT :

INCUSPAZE
2nd FLOOR

DRAWING TITLE :

RECEPTION DESK

DRAWING NUMBER

DESIGNED BY - SANSKRITI

DRAWN BY -




SCALE - N.T.S

DATE - 02-07-2022

REV. DATE -



R-552, Shankar Road,
New Rajinder Nagar, New Delhi,
Delhi 110060, INDIA

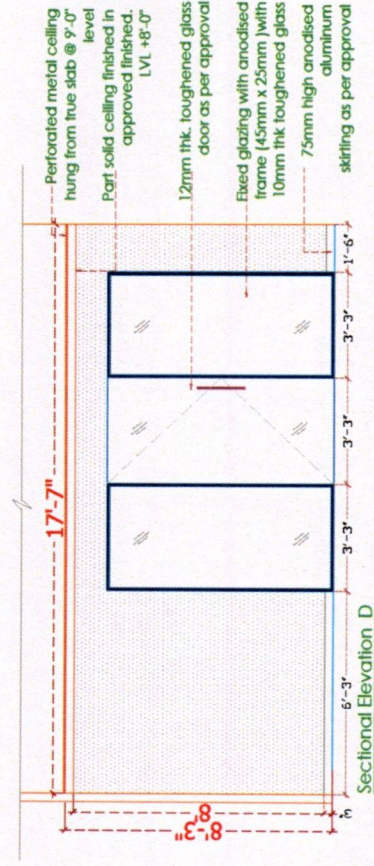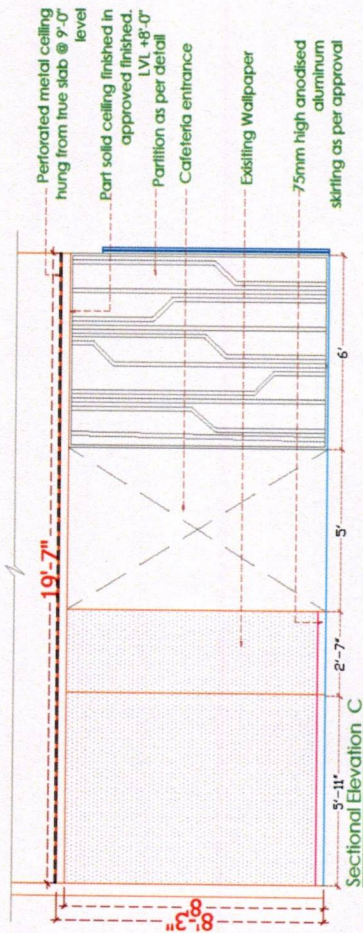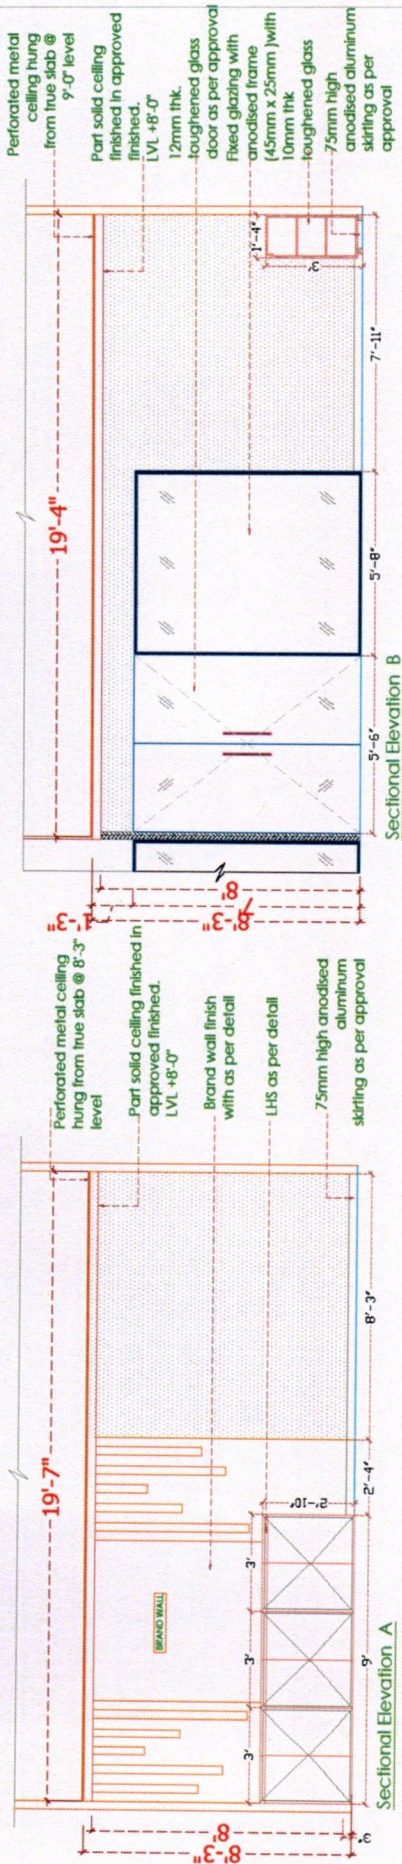

Engineers, Consultant & Turnkey Interiors

PROJECT :



R-552, Shalimar Road,
New Rajinder Nagar, New Delhi,
Delhi 110060, INDIA

DRAWING TITLE :



INCUSPAZE

RECEPTION ELEVATION

DRAWING NUMBER

DESIGNED BY -
DRAWN BY - SANSKRITI
SCALE - N.T.S
DATE - 14-06-2022
REV. DATE -


ENTRANCE

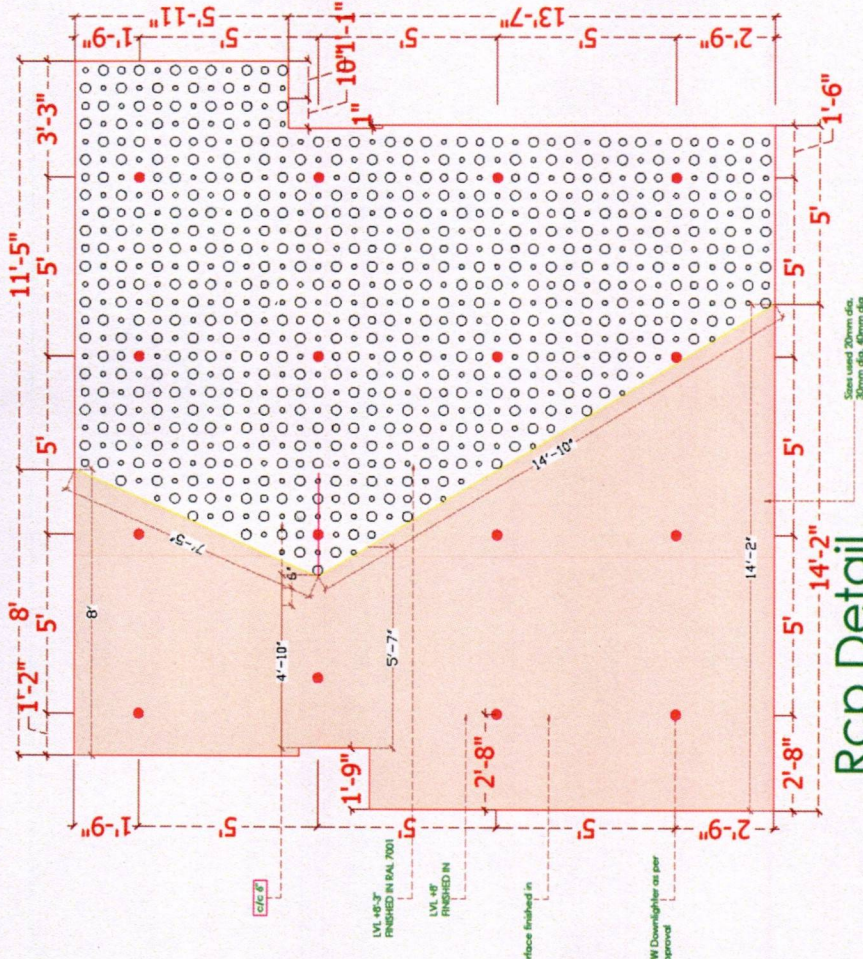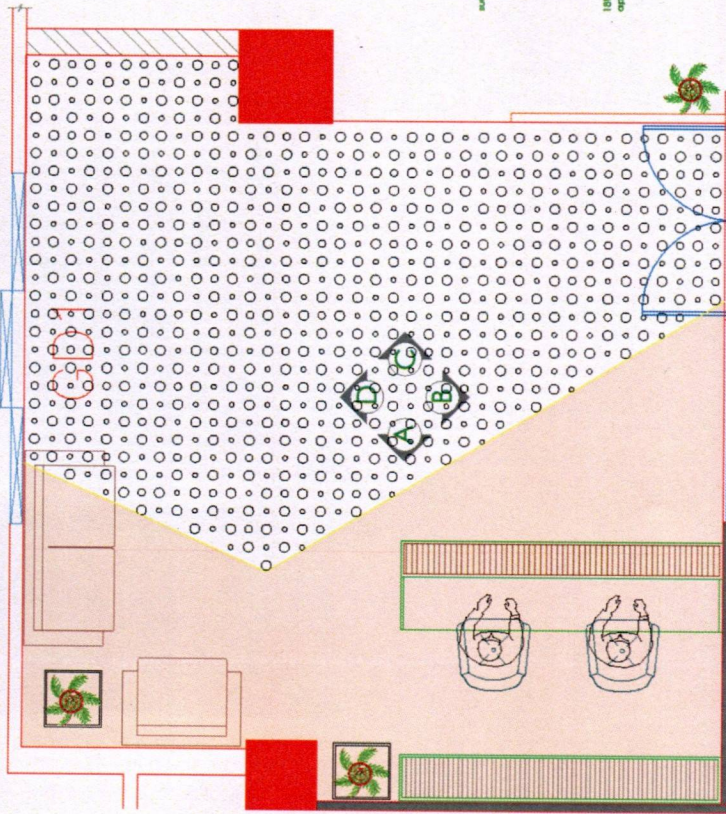


.cellign ref.jpg

REFERENCE

 Engineers, Consultant & Turnkey Interiors R-552, Shankar Road, New Rajinder Nagar, New Delhi, Delhi 110060, INDIA	PROJECT :	DRAWING TITLE :	DRAWING NUMBER	
	INCUSPAZE	RECEPTION PART PLAN	DESIGNED BY	-
			DRAWN BY	- SANSKRITI
			SCALE	- N.T.S
			DATE	- 14-06-2022
			REV. DATE	-

 


R-532, Shankar Road,
New Rajinder Nagar, New Delhi,
Delhi 110060, INDIA

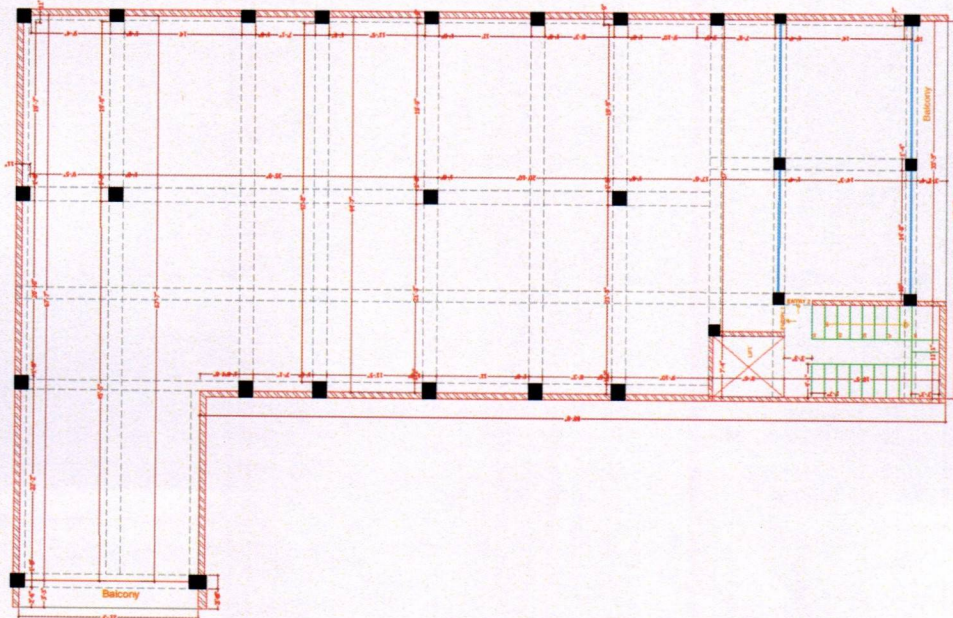


CEILING HEIGHT - 10'-3"
BEAM BOTTOM - 9'-3"
FLOOR AREA- 5172.16 SQFT

Engineers, Consultant & Turnkey Interiors K-552, Shrikrishna Road, New Indraprastha, New Delhi 110060, INDIA.	PROJECT : OFFICE, NARAINA	DRAWING TITLE : AS BUILT LAYOUT	DESIGNED BY : SANSKRITI	SCALE : N.T.S	DATE : 28-09-2022	REV. DATE :	DRAWING NUMBER : 1.1	

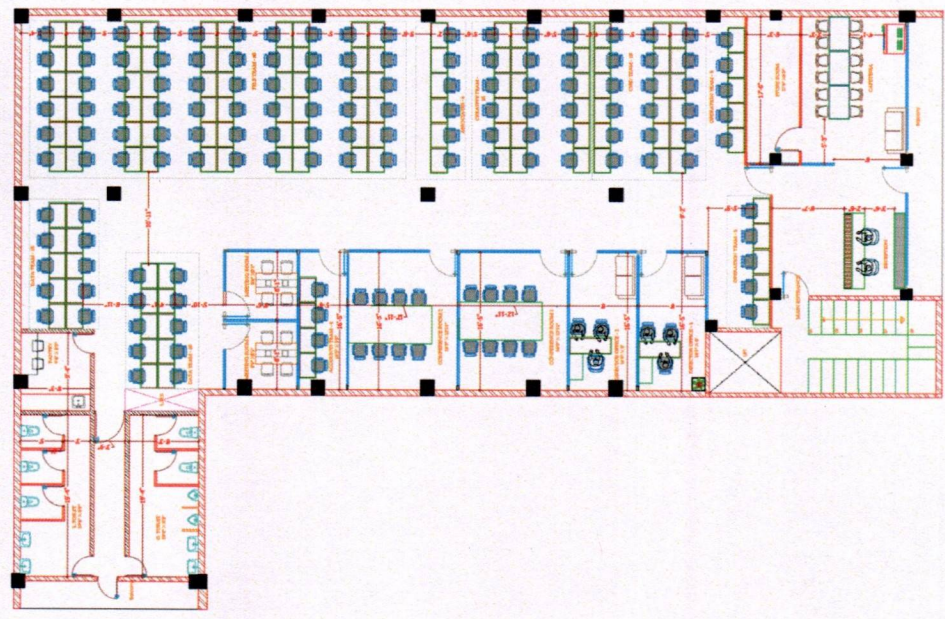


CEILING HEIGHT - 10'-3"
BEAM BOTTOM - 9'-3"
FLOOR AREA- 5172.16 SQFT


Engineers, Consultant & Turnkey Interiors K-552, Shrikrishna Road, New Indraprastha, New Delhi 110060, INDIA.	PROJECT : OFFICE, NARAINA	DRAWING TITLE : FURNITURE LAYOUT	DESIGNED BY : SANSKRITI	SCALE : N.T.S	DATE : 01.09.2022	REV. DATE :	DRAWING NUMBER : 1.1	

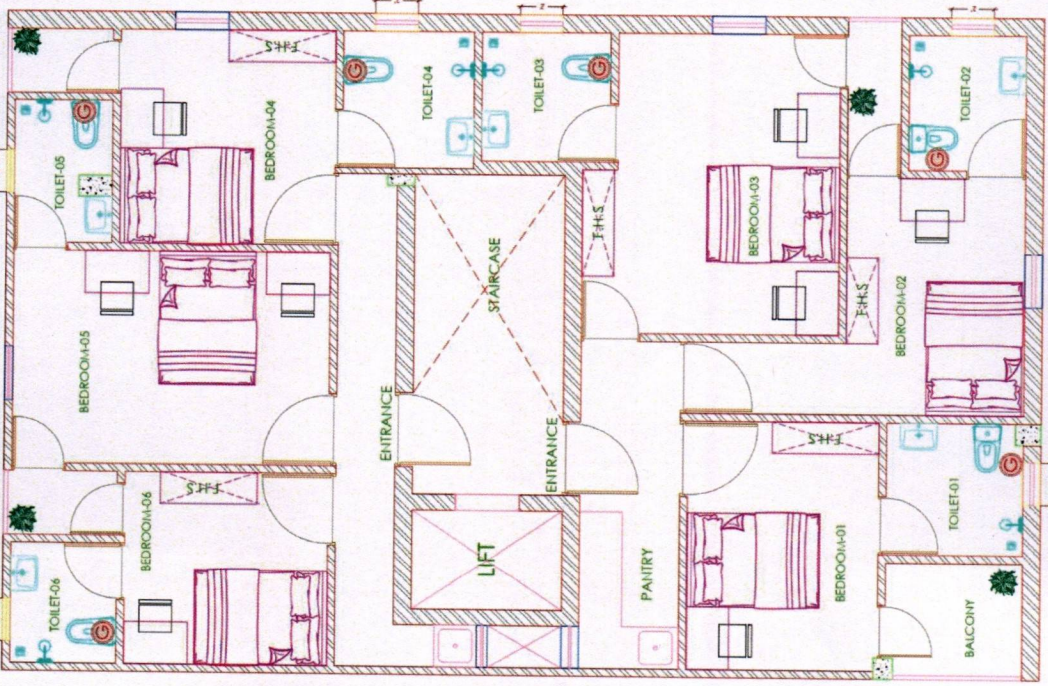


Engineers, Consultant & Turnkey Interior	PROJECT :	RAJENDER NAGAR	DRAWING TITLE :	FURNITURE LAYOUT	DESIGNED BY :	SANDHITH	DRAWING NUMBER :
8-552, Shankar Road, New Rajendra Nagar, New Delhi Delhi 110060, INDIA.	PROJECT :	RAJENDER NAGAR	DRAWING TITLE :	FURNITURE LAYOUT	DRAWN BY :	N.T.S	
					DATE :	03.10.2022	
					REV. DATE :		

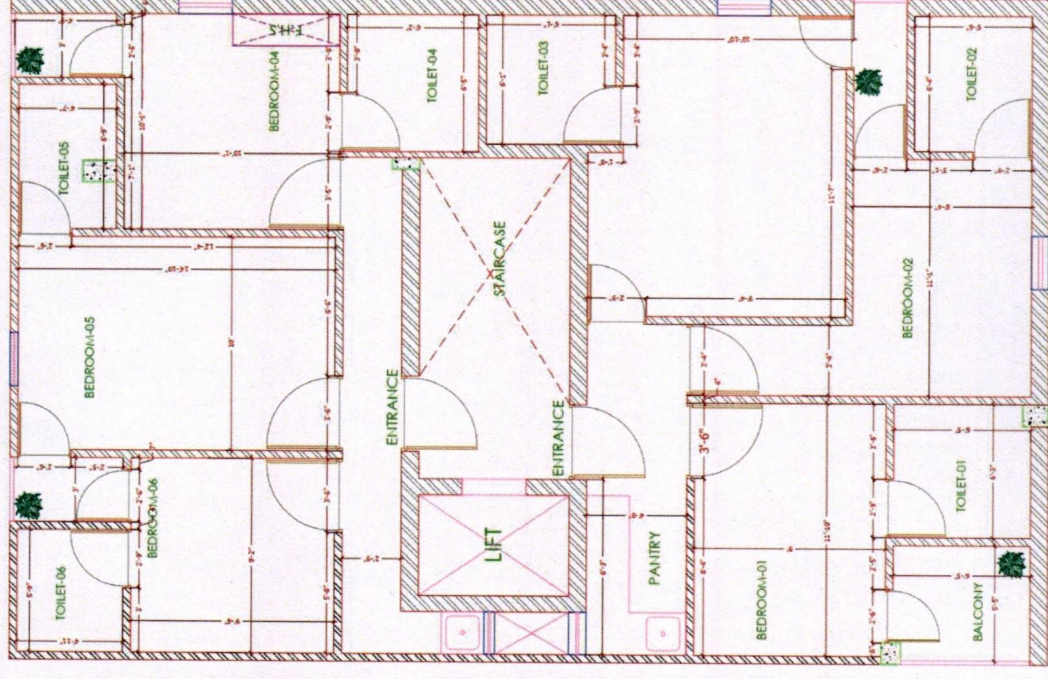

Engineers, Consultant & Turnkey Interior	PROJECT :	RAJENDER NAGAR	DRAWING TITLE :	AS-BUILT LAYOUT	DESIGNED BY :	SANDHITH	DRAWING NUMBER :
8-552, Shankar Road, New Rajendra Nagar, New Delhi Delhi 110060, INDIA.	PROJECT :	RAJENDER NAGAR	DRAWING TITLE :	AS-BUILT LAYOUT	DRAWN BY :	N.T.S	
					DATE :	03.10.2022	
					REV. DATE :		

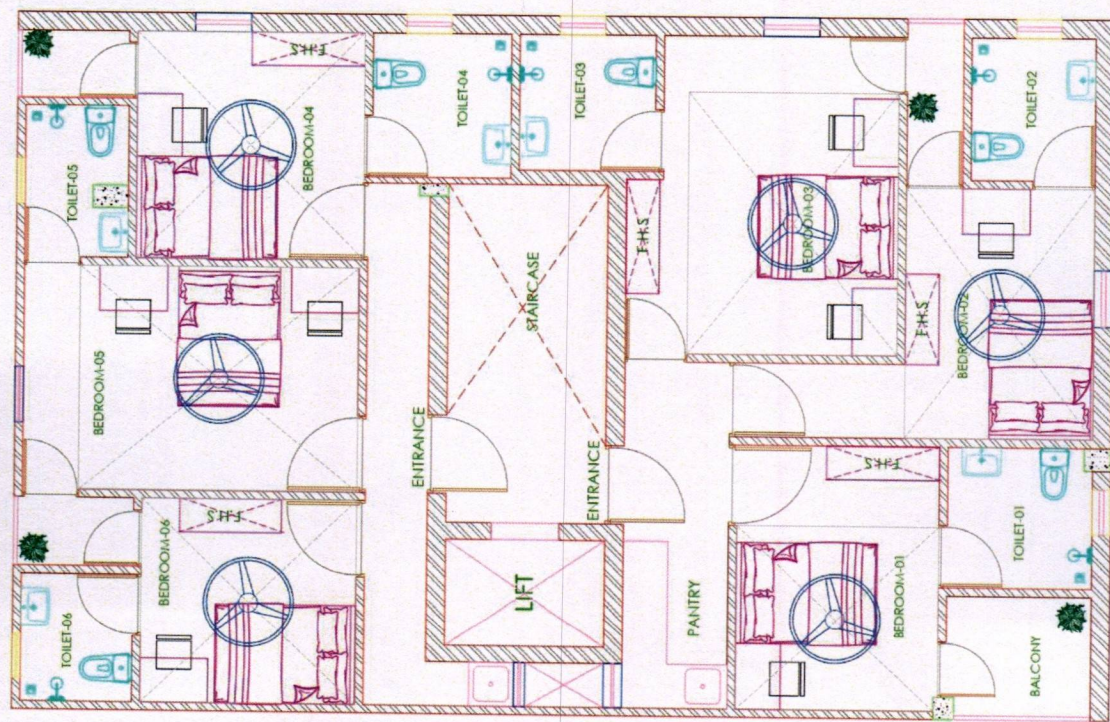

 Engineers, Consultant & Turnkey Interiors	PROJECT	RAVENDER NAGAR	DRAWING TITLE :		DRAWING NUMBER
			CEILING ELECTRICAL LAYOUT		
			DESIGNED BY	= SANSKRITI	
			DRAWN BY	= N.L.S	
			SCALE	=	
 R-552, Shankar Road, New Rajinder Nagar, New Delhi-110060, INDIA.			DATE	= 04.10.2022	
			REV. DATE	=	

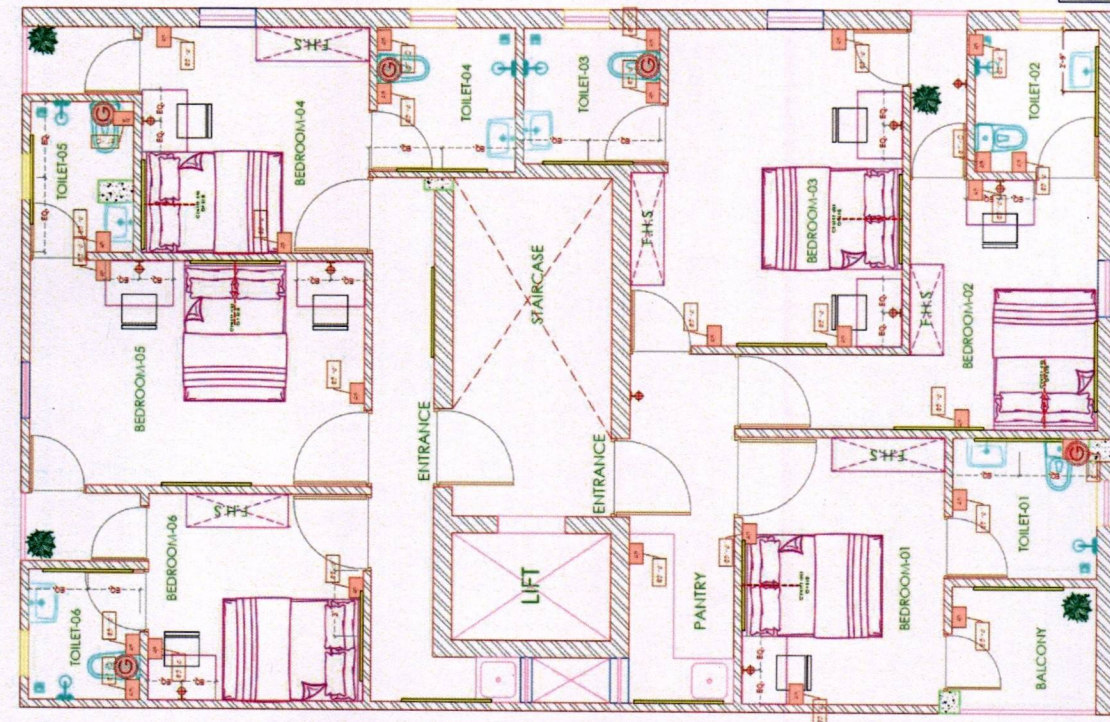


Engineers, Consultant & Turnkey Interior	PROJECT :	RAJENDER NAGAR	DRAWING TITLE :		DRAWING NUMBER
			WALL ELECTRICAL LAYOUT		
			DESIGNED BY	-- SANSKRITI --	
			DRAWN BY	-- N.L.S --	
			SCALE	-- 0.5/10.2022 --	
sf	R-552, Shankar Road, New Rajinder Nagar, New Delhi-110060, INDIA.	REV. DATE	DATE	DATE	REV. DATE
			DATE	DATE	
			DATE	DATE	

TOILET	TOILET	TOILET
TOILET	TOILET	TOILET
TOILET	TOILET	TOILET


APC OFFICE
LOCATION- PALAM VIHAR
AREA- 2038 SQ. FT

- EXISTING WALLS
- COLUMN
- 6" BRICK WALL
- HALF HEIGHT SOLID PLY PARTITION TILL 4'
- GLASS PARTITION TILL 8'
- SOLID FULL HEIGHT PLY PARTITION

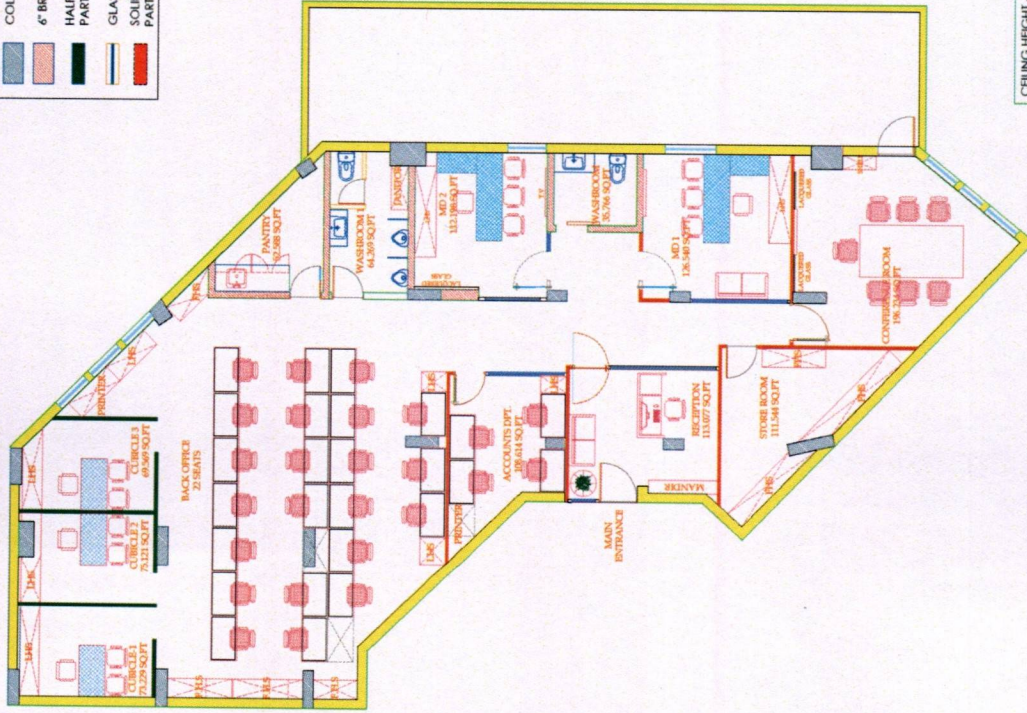


Engineers, Consultant & Turnkey Interior	 sf R-552, Sharker Road, New Rohini Nagar, New Delhi Delhi 110060, INDIA.	PROJECT :	APC OFFICE PALAM VIHAR	DRAWING TITLE :	FURNITURE LAYOUT	DESIGNED BY :	—	DRAWN BY :	—	SCALE :	—	DATE :	—	REV.	DATE :	—	DRAWING NUMBER	1.1
						SANDESHI	N.T.S		3.09.2022		8.11.2022							

- EXISTING WALLS
- COLUMN
- 6" BRICK WALL
- HALF HEIGHT SOLID PLY PARTITION TILL 4'
- GLASS PARTITION TILL 8'
- SOLID FULL HEIGHT PLY PARTITION

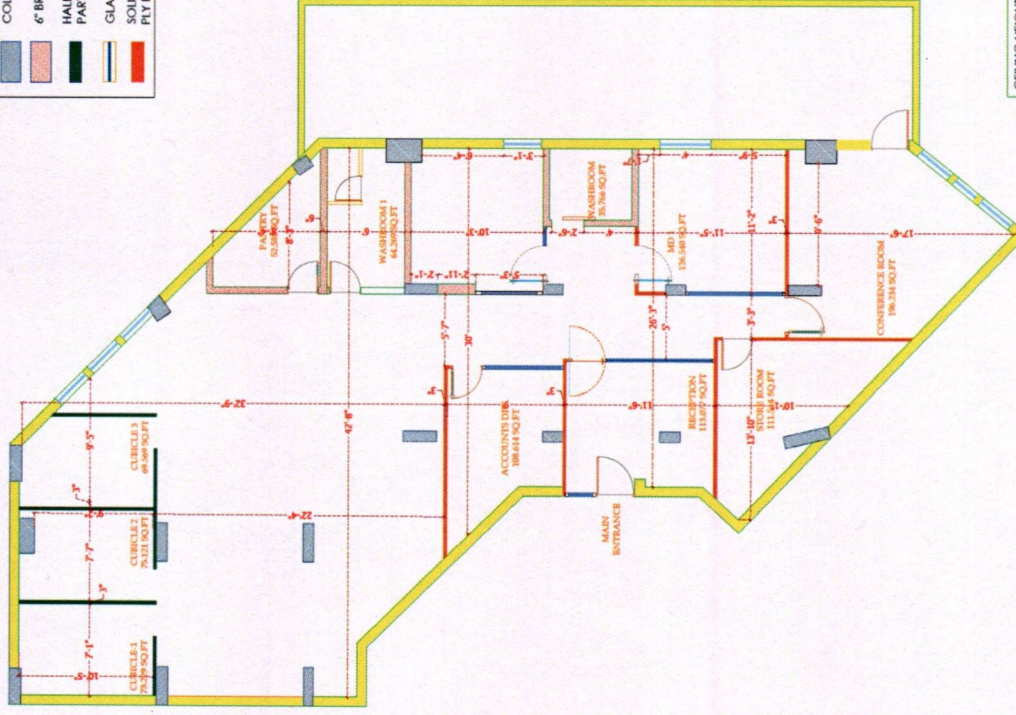

Engineers, Consultant & Turnkey Interiors	PROJECT :	APC OFFICE PALAM VIHAR	DRAWING TITLE :	CIVIL AND PARTITION LAYOUT	DESIGNED BY :	--	SANDESHI	DRAWN BY :	--	SANDESHI	SCALE :	--	N.T.S	DATE :	--	3.08.2022	REV.	DATE :	--	8.11.2022	DRAWING NUMBER	1.1
R-552, Sharker Road, New Rohini Nagar, New Delhi, Delhi 110060, INDIA.																						

- EXISTING WALLS
- COLUMN
- 6" BRICK WALL
- HALF HEIGHT SOLID PLY PARTITION TILL 4'
- GLASS PARTITION TILL 8'
- SOLID FULL HEIGHT PLY PARTITION

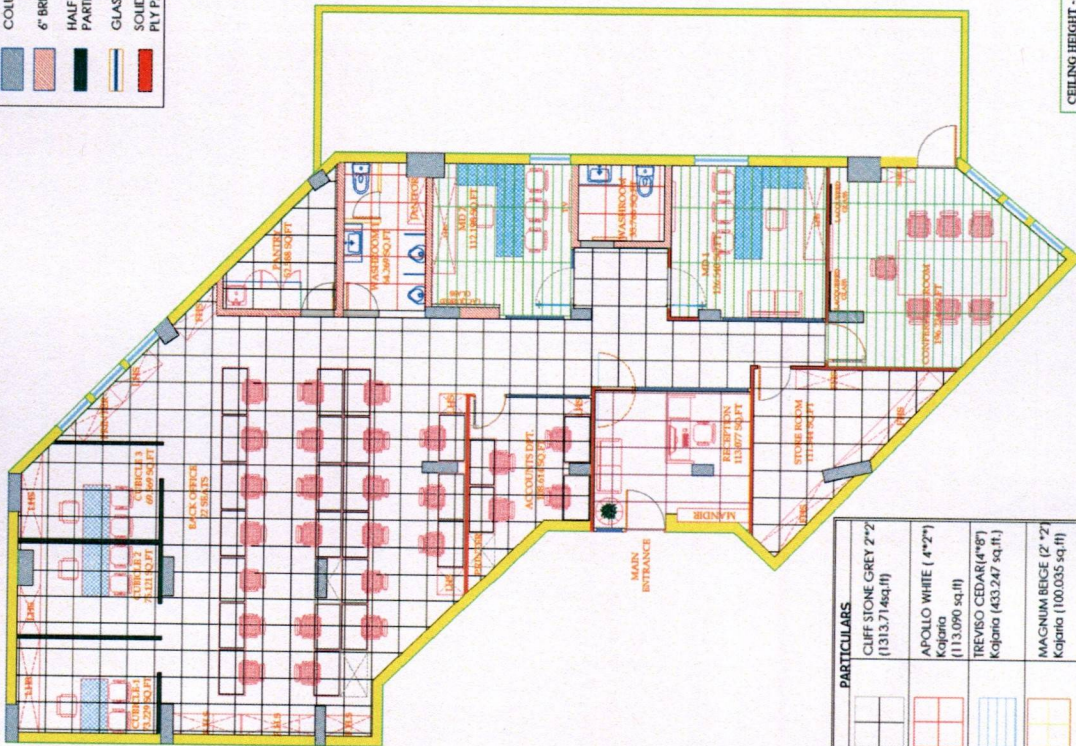


PARTICULARS	
CLIFF STONE GREY (2'x2') (1313.714sq.ft)	
APOLLO WHITE (4'x2') Kojala (113.090 sq.ft)	
TREVISO CEDAR (4'x8') Kojala (433.247 sq.ft.)	
MAGNUM BEIGE (2'x2') Kojala (100.035 sq.ft)	
Granite (6.08 sq. ft)	

CEILING HEIGHT - 9'9"
BEAM BOTTOM - 8'9"
FLOOR AREA 2234 SQFT

Engineers, Consultant & Turnkey Interior	PROJECT :	APC OFFICE PALAM VIHAR	DRAWING TITLE :	FLOORING LAYOUT	DESIGNED BY :	SAHSHRITI	DRAWING NUMBER :	1,1
					DRAWN BY :	SAHSHRITI		
					SCALE :	N.T.S		
					DATE :	3.09.2022		
					REV. DATE :	8.11.2022		

sf
R-552, Shankar Road,
New Kailash Nagar, New Delhi
110060, INDIA

- EXISTING WALLS
- COLUMN
- 6" BRICK WALL
- HALF HEIGHT SOLID PLY PARTITION TILL 4'
- GLASS PARTITION TILL 8'
- SOLID FULL HEIGHT PLY PARTITION

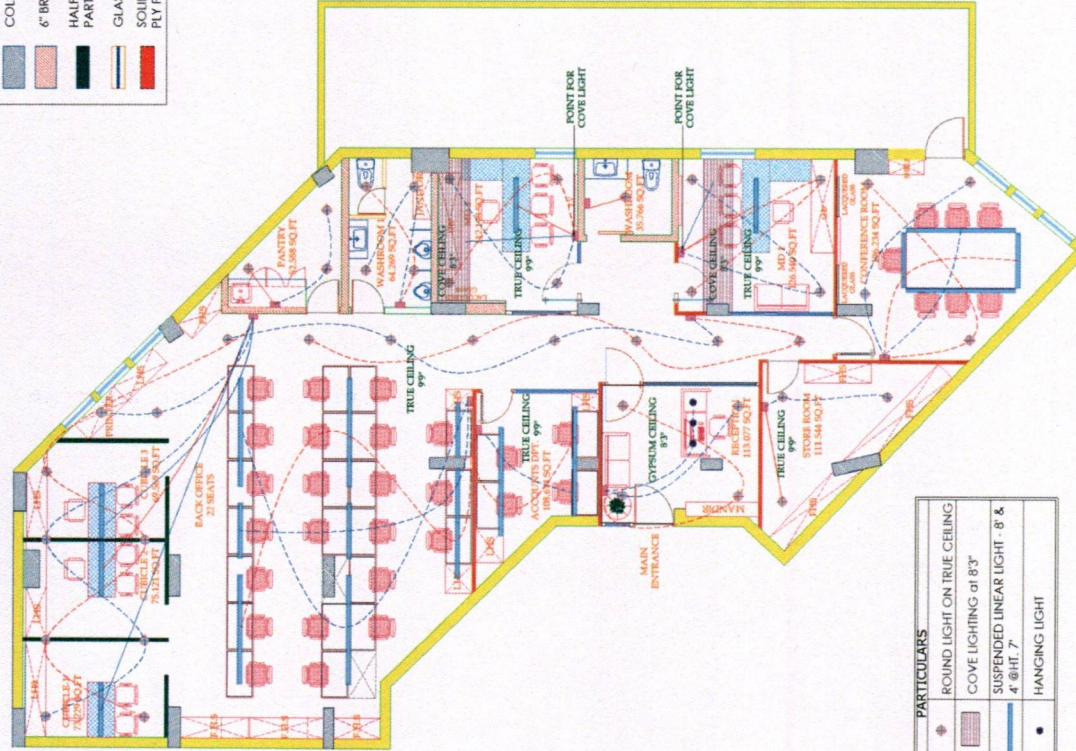


PARTICULARS	
ROUND LIGHT ON TRUE CEILING	
COVE LIGHTING at 8'3"	
SUSPENDED LINEAR LIGHT - 8' & 4' @ HT. 7'	
HANGING LIGHT	

CEILING HEIGHT - 9'9"
BEAM BOTTOM - 8'9"
FLOOR AREA 2234 SQFT

Engineers, Consultant & Turnkey Interior	PROJECT :	APC OFFICE PALAM VIHAR	DRAWING TITLE :	LOOPING	DESIGNED BY :	SAHSHRITI	DRAWING NUMBER :	1,1
					DRAWN BY :	SAHSHRITI		
					SCALE :	N.T.S		
					DATE :	3.09.2022		
					REV. DATE :	30.11.2022		

sf
R-552, Shankar Road,
New Kailash Nagar, New Delhi
110060, INDIA

- EXISTING WALLS
- COLUMN
- 6" BRICK WALL
- HALF HEIGHT SOLID PLY PARTITION TILL 4'
- GLASS PARTITION TILL 8'
- SOLID FULL HEIGHT PLY PARTITION

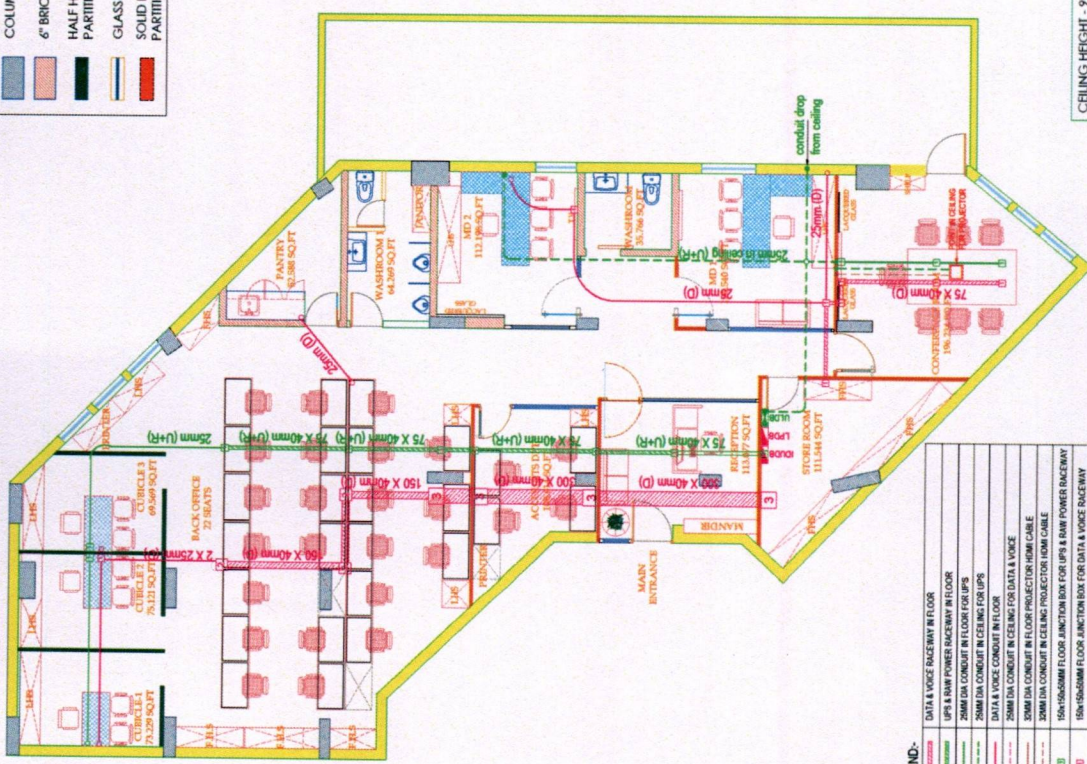

CEILING HEIGHT - 9'9"
BEAM BOTTOM - 8'9"
FLOOR AREA 2234 SQ.FT

LEGEND:-

DATA & VOICE RACEWAY IN FLOOR
UPS & BATT POWER RACEWAY IN FLOOR
20MM DIA CONDUIT IN FLOOR FOR UPS
20MM DIA CONDUIT IN FLOOR FOR UPS
DATA & VOICE CONDUIT IN FLOOR
20MM DIA CONDUIT IN CEILING FOR DATA & VOICE
20MM DIA CONDUIT IN FLOOR PROJECTOR HOME CABLE
20MM DIA CONDUIT IN CEILING PROJECTOR HOME CABLE
15MM SHAMAM FLOOR JUNCTION BOX FOR UPS & BATT POWER RACEWAY
15MM SHAMAM FLOOR JUNCTION BOX FOR DATA & VOICE RACEWAY
20MM SHAMAM FLOOR JUNCTION BOX FOR DATA & VOICE RACEWAY
20MM SHAMAM FLOOR JUNCTION BOX FOR DATA & VOICE RACEWAY
FOUR WAY CONDUIT JUNCTION BOX
CONDUIT DROP FROM CEILING


Engineers, Consultant & Turnkey Interior PROJECT : APC OFFICE PALAM VIHAR

DRAWING TITLE : FURNITURE LAYOUT

DESIGNED BY : SANSKRITI
DRAWN BY : SANSKRITI
SCALE : N.T.S
DATE : 3.09.2022
REV. DATE : 6.11.2022

DRAWING NUMBER : 1.1

- EXISTING WALLS
- COLUMN
- 6" BRICK WALL
- HALF HEIGHT SOLID PLY PARTITION TILL 4'
- GLASS PARTITION TILL 8'
- SOLID FULL HEIGHT PLY PARTITION

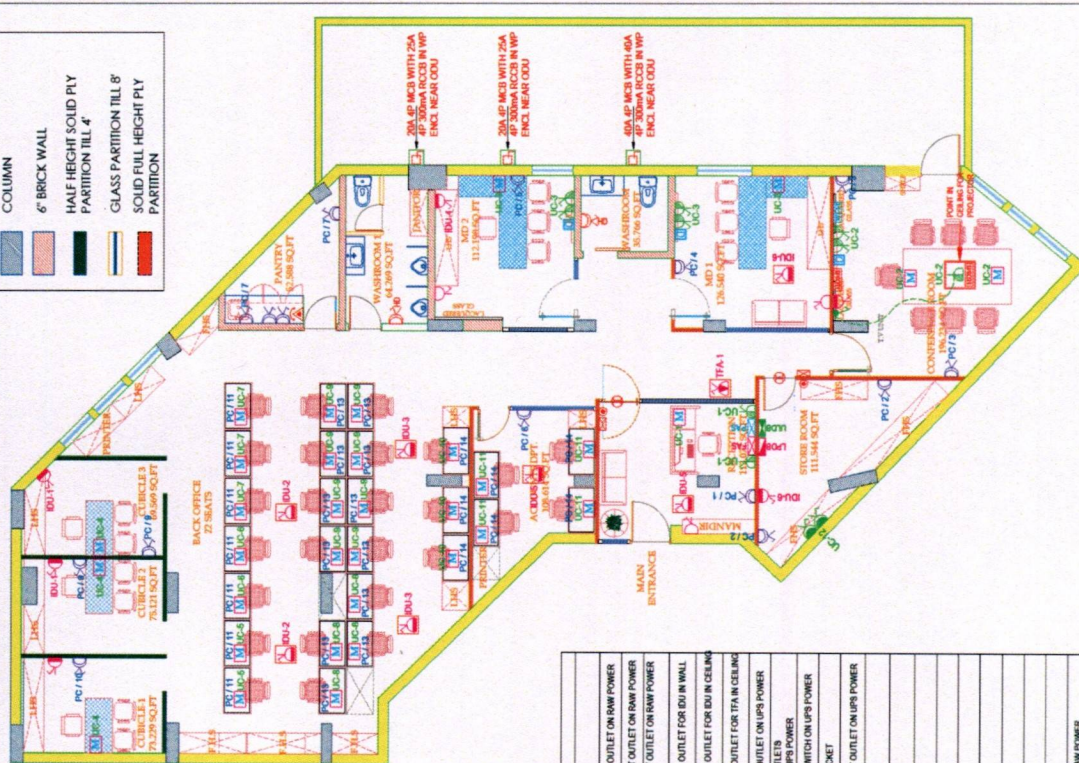

CEILING HEIGHT - 9'9"
BEAM BOTTOM - 8'9"
FLOOR AREA 2234 SQ.FT

ELECTRICAL LEGEND :-







6A 3 PIN SWITCHED SOCKET OUTLET ON RAW POWER
6A 3 PIN SWITCHED SOCKET OUTLET ON RAW POWER
6A 3 PIN SWITCHED SOCKET OUTLET ON RAW POWER
6A 3 PIN SWITCHED SOCKET OUTLET ON RAW POWER
6A 3 PIN SWITCHED SOCKET OUTLET FOR DU IN WALL
6A 3 PIN SWITCHED SOCKET OUTLET FOR DU IN CEILING
6A 3 PIN SWITCHED SOCKET OUTLET FOR ITA IN CEILING
240V 6A 3 PIN SOCKETS OUTLETS WITH 1 NO. 16A SWITCH ON UPS POWER
6A 3 PIN SOCKET WITHOUT SWITCH ON UPS POWER
6A SWITCH TO CONTROL SOCKET
6A 3 PIN SWITCHED SOCKET OUTLET ON UPS POWER
DATA OUTLET
TELEPHONE OUTLET
DATA DATA OUTLET
HEIM PORT
MAGNETIC DOOR LOCK
CARD READER
EXIT PUSH BUTTON
FIRE ALARM PANEL
PUBLIC ADDRESS SYSTEM
DISTRIBUTION BOARD FOR RAW POWER
DISTRIBUTION BOARD FOR UPS POWER

Engineers, Consultant & Turnkey Interior PROJECT : APC OFFICE PALAM VIHAR

DRAWING TITLE : ELECTRICAL LAYOUT

DESIGNED BY : SANSKRITI
DRAWN BY : SANSKRITI
SCALE : N.T.S
DATE : 3.09.2022
REV. DATE : 6.11.2022

DRAWING NUMBER : 1.1

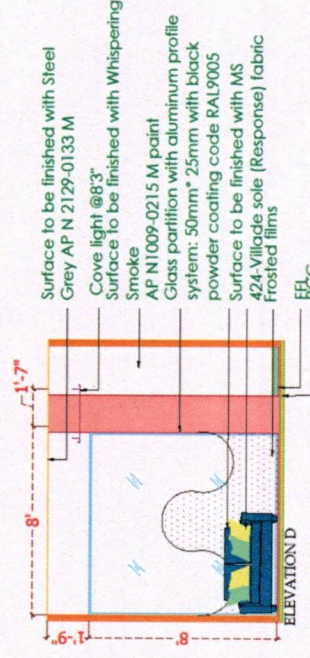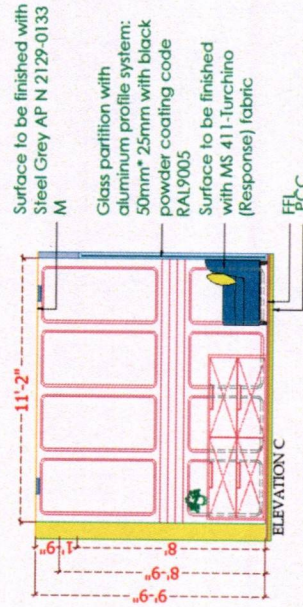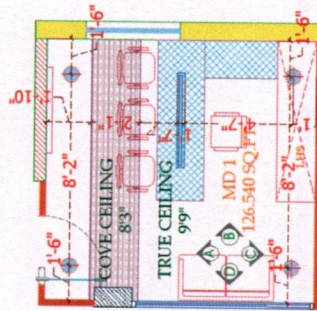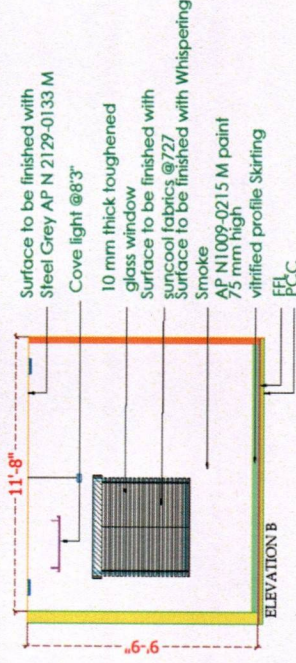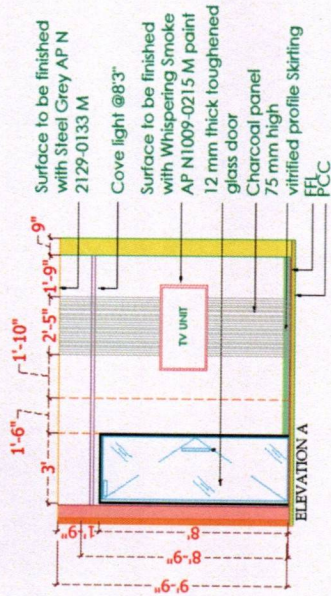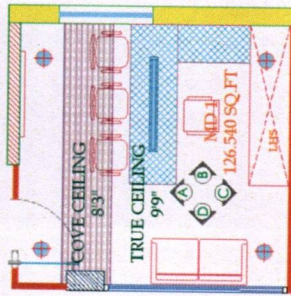

CEILING HEIGHT - 9'9"
BEAM BOTTOM - 8'9"
FLOOR AREA 2234 SQFT

Engineers, Consultant & Turnkey Interiors

PROJECT :

APC OFFICE
PALAM VIHAR


DRAWING TITLE :







CONFERENCE ROOM

DRAWING NUMBER

DESIGNED BY	-
DRAWN BY	- SANSKRITI
SCALE	- N.T.S
DATE	- 24-11-2022
REV. DATE	-

 R-552, Shankar Road,
New Rajinder Nagar, New Delhi,
Delhi 110060, INDIA.



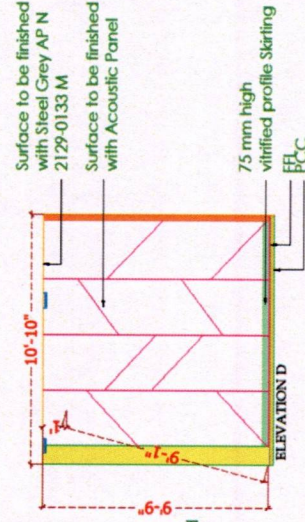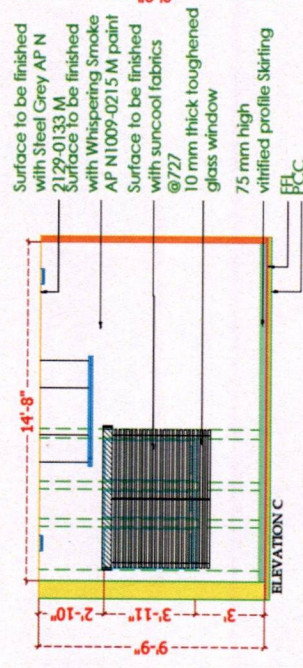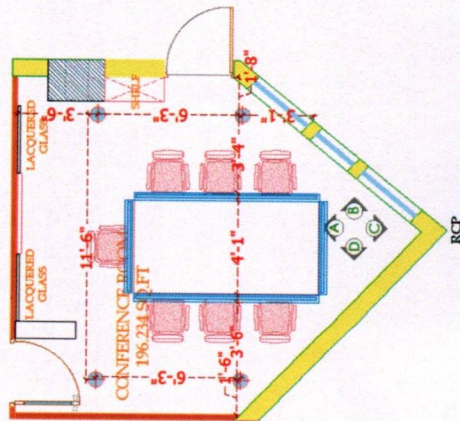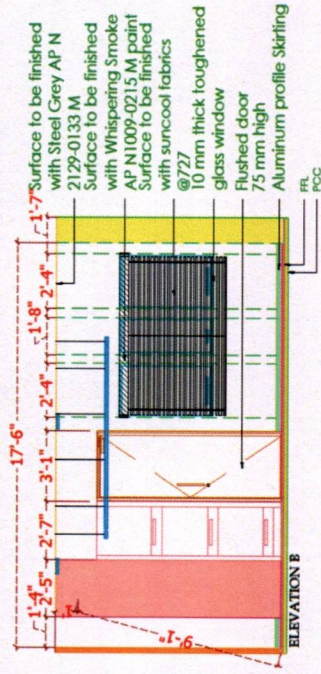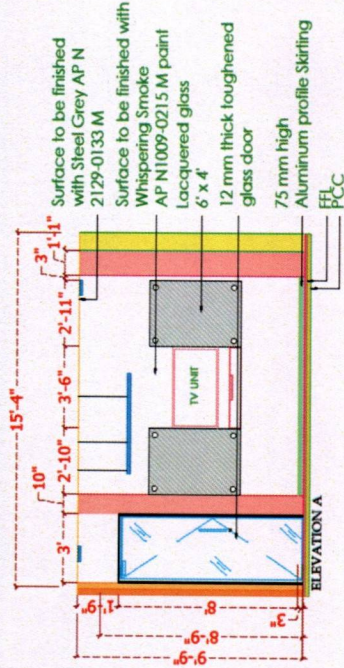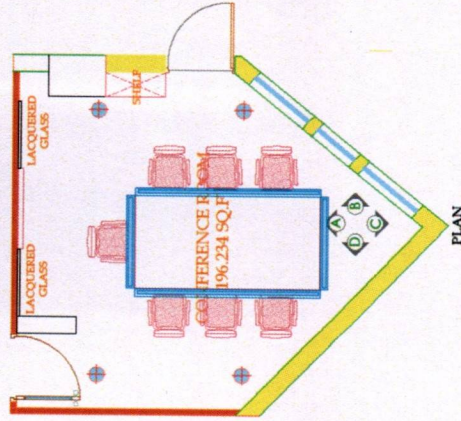

CEILING HEIGHT - 9'9"
BEAM BOTTOM - 8'9"
FLOOR AREA 2234 SQFT

Engineers, Consultant & Turnkey Interiors



R-552, Shankar Road,
New Rajinder Nagar, New Delhi,
Delhi 110060, INDIA.

PROJECT :



APC OFFICE
PALAM VIHAR

DRAWING TITLE :

CONFERENCE ROOM






DRAWING NUMBER

DESIGNED BY	—
DRAWN BY	— SANSKRITI
SCALE	— N.T.S
DATE	— 24-11-2022
REV. DATE	—

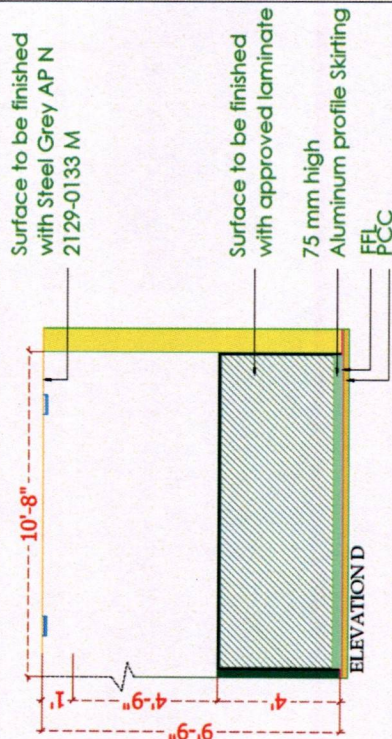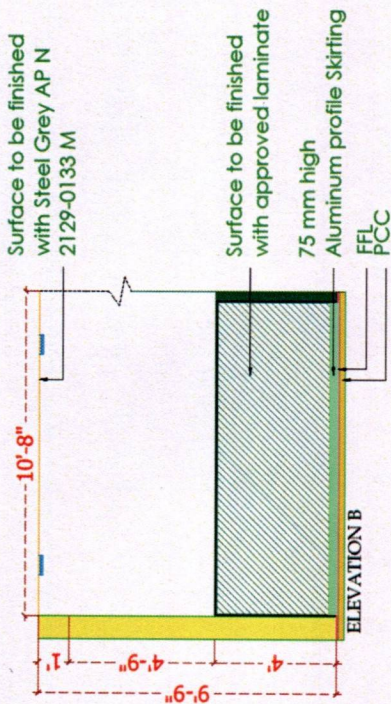

CEILING HEIGHT - 9'9"
BEAM BOTTOM - 8'9"
FLOOR AREA 2234 SQFT

 Engineers, Consultant & Turnkey Interiors R-552, Shankar Road, New Rajinder Nagar, New Delhi, Delhi 110060, INDIA.	PROJECT : APC OFFICE PALAM VIHAR	DRAWING TITLE : CUBICLE		DRAWING NUMBER	
				DESIGNED BY	-
				DRAWN BY	- SANSKRITI
				SCALE	- N.T.S
				DATE	- 24-11-2022
				REV. DATE	-

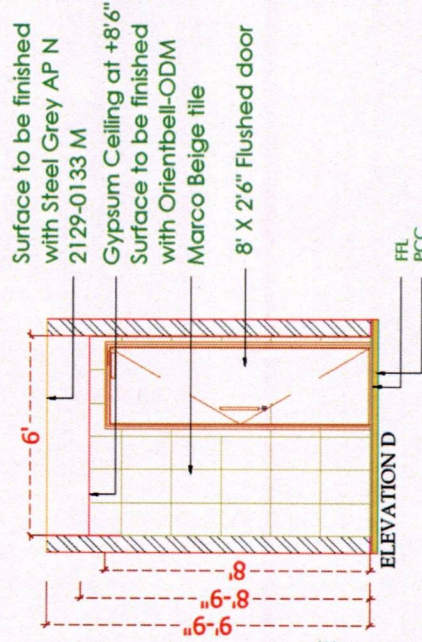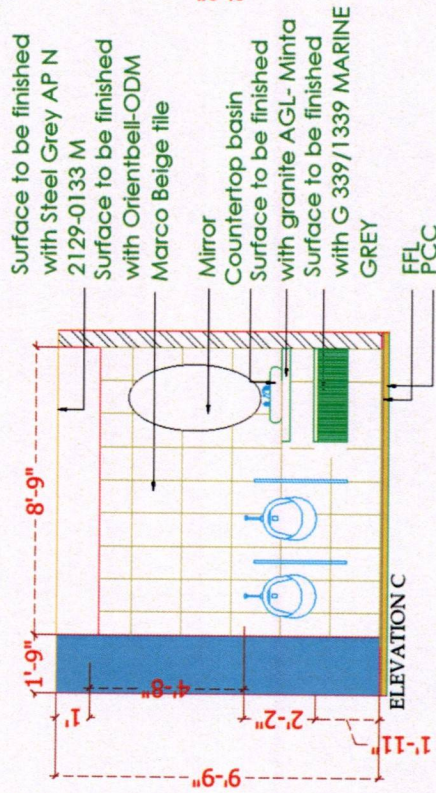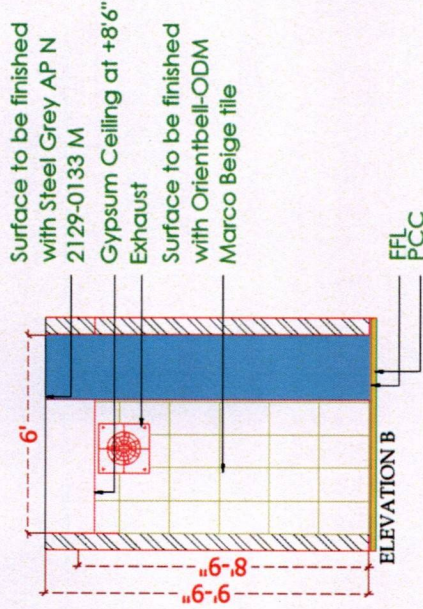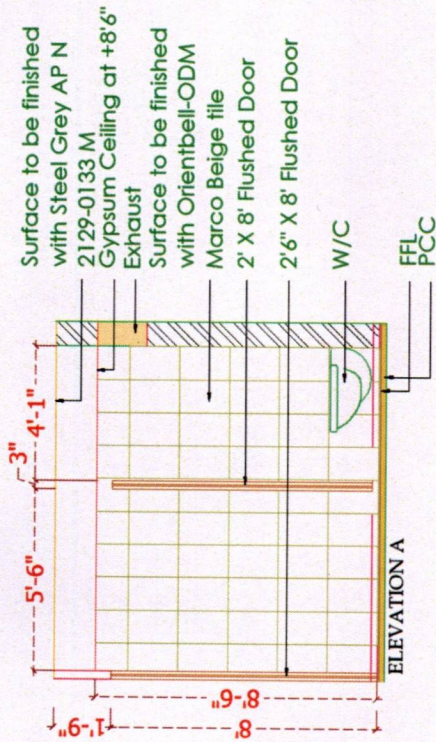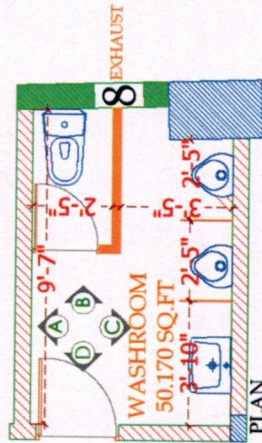

CEILING HEIGHT - 9'9"
BEAM BOTTOM - 8'9"
FLOOR AREA 2234 SQFT

Engineers, Consultant & Turnkey Interiors

PROJECT :

APC OFFICE
PALAM VIHAR

DRAWING TITLE :

WASHROOM

DRAWING NUMBER

DESIGNED BY -
DRAWN BY - SANSKRITI
SCALE - N.T.S
DATE - 28-09-2022
REV. DATE -

R-552, Shankar Road,
New Rajinder Nagar, New Delhi,
Delhi 110060, INDIA.



	Engineers, Consultant & Turnkey Interiors	PROJECT : APC OFFICE PALAM VIHAR	DRAWING TITLE : RECEPTION	DRAWING NUMBER	
				DESIGNED BY	-
				DRAWN BY	- SANSKRITI
				SCALE	- N.T.S
				DATE	- 13-09-2022
				REV. DATE	
R-552, Shankar Road, New Rajinder Nagar, New Delhi, Delhi 110060, INDIA.					

THANK YOU